

PILO ENGINEERING
540 H/BISCUS BLVD
MERRITT ISLAND, FL 32952
(321) 427-3644
JAP-PILOENG@CFL.RR.COM
WWW.PILOENGINEERING.COM
F.L.C.A. # 26294

MICHAEL PILO, PE
FL P.E. # 50067

LEGEND

- | | | | | | |
|-------------|---|--------------------------|----------|---|----------------------------|
| AMP | - | AMPERE, AMPS | | | |
| AFC | - | ABOVE FINISHED COUNTER | LB | - | POUND |
| AF | - | ABOVE FINISHED FLOOR | L.F.T. | - | LINEAR FEET |
| AFG | - | ABOVE FINISHED GRADE | LPS | - | LOW PRESSURE SODIUM |
| AHU | - | AIR HANDLING UNIT | LV | - | LOW VOLTAGE |
| AIC | - | AMPS INTERRUPTING | | | |
| CAPACITY | | | MCM | - | THOUSAND CIRCULAR MILS |
| AUX | - | AUXILIARY | MECH | - | MECHANICAL |
| AMP | - | AMPERES | MCP | - | MOTOR CIRCUIT PROTECTION |
| A/C | - | AIR CONDITIONING | MH | - | MANHOLE |
| AC | - | ALTERNATING CURRENT | M.O.O. | - | MOTOR OPERATED |
| ATS | - | AUTOMATIC TRANSFER | MPS | - | MANUAL PULL STATION |
| SWITCH | | | MTR | - | MOTOR |
| AWG | - | AMERICAN WIRE GAUGE | | | |
| | | | N/A | - | NOT APPLICABLE |
| BFF | - | BELOW FINISHED FLOOR | NC | - | NORMALLY CLOSED |
| BFG | - | BELOW FINISHED GRADE | NIC | - | NOT IN CONTRACT |
| BIL | - | BASIC INSULATION IMPULSE | NO | - | NORMALLY OPEN |
| LEVEL | | | NTS | - | NOT TO SCALE |
| BC | - | BARE COPPER | NEC | - | NATIONAL ELECTRICAL CODE |
| BD | - | BYPASS DAMPERS | | | |
| BLDG | - | BUILDING | O2, 0 | - | OXYGEN |
| BOM | - | BILL OF MATERIAL | OA | - | OUTSIDE AIR |
| | | | OC | - | ON CENTER |
| C, CDT | - | CONDUIT | OD | - | OUTSIDE DIAMETER |
| CB | - | CIRCUIT BREAKER | OPP | - | OPPOSITE |
| CF | - | COMPACT FLUORESCENT | OVHD | - | OVERHEAD |
| CFM | - | CUBIC FEET PER MINUTE | | | |
| CKT | - | CIRCUIT | PA | - | PUBLIC ADDRESS |
| CLG | - | CEILING | PAW | - | PAGING AREA WARNING |
| CONC | - | CONCRETE | PB, PBX | - | PULL BOX, PUSH BUTTON |
| CONT | - | CONTINUED, CONTINUATION, | PL | - | PLACES |
| CONTROL | | | PNL | - | PANEL, PANELBOARD |
| CU | - | COPPER | PRESS | - | PRESSURE |
| CONC | - | CONCRETE | PRV | - | POWERED ROOF VENT |
| CMU | - | CONCRETE MASONRY UNIT | PVC | - | POLYVINYL CHLORIDE |
| | | | | | |
| DIA (Ø) | - | DIAMETER | QTY | - | QUANTITY |
| DIM | - | DIMENSION | | | |
| DISC | - | DISCONNECT | R | - | RESISTANCE |
| DN | - | DOWN | REF | - | REFERENCE |
| DWG | - | DRAWING | RGS | - | RIGID GALVANIZED STEEL |
| EA | - | EACH | RM | - | ROOM |
| EL | - | ELEVATION | | | |
| ELEC | - | ELECTRIC | SAN | - | SANITARY |
| EMT | - | ELECTRICAL METALLIC | S | - | SERVICE ENTRANCE |
| TUBING | | | SHT | - | SHEET |
| EOP | - | EDGE OF PAVEMENT | SIG | - | SIGNAL (SIGNALING) CIRCUIT |
| EXH | - | EXHAUST | SQ. FT. | - | SQUARE FOOT, SQUARE FEET |
| EXIST | - | EXISTING | SW | - | SWITCH |
| | | | SYS | - | SYSTEM |
| FA | - | FIRE ALARM | ST, STL. | - | STAINLESS STEEL |
| FACP | - | FIRE ALARM CONTROL PANEL | STL | - | STEEL |
| FCU | - | FAN COIL UNIT | SPEC | - | SPECIFICATIONS |
| | | | | | |
| FLA | - | FULL LOAD AMPS | TEMP | - | TEMPERATURE |
| FLEX | - | FLEXIBLE | TMCB | - | THERMAL MAGNETIC CIRCUIT |
| FT | - | FEET | BREAKER | | |
| FAC | - | FACILITY | TRANSF | - | TRANSFORMER |
| | | | TYP | - | TYPICAL |
| GF1 | - | GROUND FAULT | | | |
| INTERRUPTER | | | | | |
| GN | - | GROUND | UF | - | UNDER FLOOR |
| GB | - | GROUND BAR | UG | - | UNDERGROUND |
| GEN | - | GENERATOR | UON | - | UNLESS OTHERWISE NOTED |
| GF | - | GROUND FAULT | | | |
| | | | VERT | - | VERTICAL |
| HDWR | - | HARDWARE | | | |
| HORIZ | - | HORIZONTAL | W | - | WATT |
| HP | - | HORSEPOWER | W/ | - | WITH |
| HWG | - | HEAVY WALL GALVANIZED | W/O | - | WITHOUT |
| CONDUIT | | | WP | - | WEATHERPROOF |
| | | | WTR | - | WATER |
| | | | W | - | WIRE |
| I | - | CURRENT | | | |
| ID | - | INSIDE DIAMETER | | | |
| IDS | - | INSTRUCTION DETECTION | XFMR | - | TRANSFORMER |
| SYSTEM | | | | | |
| IN | - | INCH, INCHES | | | |
| | | | | | |
| KV, KV | - | KILOVOLTS | | | |
| KW | - | KILOWATT | | | |

- | | |
|--|---|
| | PANEL BOARD - 480/277 VOLTS. |
| | PANEL BOARD - 120/208 VOLTS. |
| | JUNCTION BOX. |
| | DISCONNECT SWITCH, NEMA 1 (INDOOR), NEMA 4X (OUTDOOR) |
| | 125V AC 20 AMP DUPLEX RECEPTACLE
INSTALLED AT 18" AFF OR AS REQUIRED BY OWNER. |
| | 125V AC 20 AMP QUAD RECEPTACLE
INSTALLED AT 18" AFF OR AS REQUIRED BY OWNER. |
| | 125V AC 20 AMP DUPLEX GFI RECEPTACLE INSTALLED
AT 18" A.F.F. |
| | 208V AC, 30 AMP RECEPTACLE - EXACT REQUIREMENT
TO BE COORDINATED WITH OWNER |
| | 208V AC, 60 AMP, 3PH, 5-WIRE RECEPTACLE - MELTRIC |
| | 125V AC 20 AMP DUPLEX RECEPTACLE
INSTALLED AT 48" AFF OR AS REQUIRED BY OWNER. |
| | 125V AC 20 AMP DUPLEX GFI RECEPTACLE
INSTALLED AT 48" AFF OR AS REQUIRED BY OWNER. |
| | COMBINATION FLOOR MOUNTED, FLUSH, 20 AMP QUAD RECEPTACLE
AND NETWORK CONNECTION. |
| | EXHAUST FAN |
| | EXIT LIGHT WITH BATTERY BACKUP |
| | 2 X 4 RECESSED LED FIXTURE |
| | SAME AS ABOVE W/ EMERGENCY LIGHT BACKUP (WIRED AS NIGHT LIGHT) |
| | 4' LED STRIP, SURFACE MOUNTED |
| | SAME AS ABOVE W/ EMERGENCY LIGHT BACKUP (WIRED AS NIGHT LIGHT) |
| | RECESSED ROUND LED FIXTURE |
| | EXTERIOR WALL MOUNTED LED FIXTURE W/BATTERY |
| | SINGLE POLE 20 AMP LED DIMMER SWITCH, FLUSH MOUNTED IN
FINISHED AREAS. MOUNT 48" A.F.F. |
| | 3-WAY 20 AMP SWITCH, FLUSH MOUNTED IN
FINISHED AREAS. MOUNT 48" A.F.F. |
| | VACANCY SENSOR (MANUAL ON, AUTOMATIC OFF)
CEILING MOUNTED |
| | PHOTOCELL FOR EXTERIOR LIGHTING CONTROL |
| | NETWORK CONNECTION POINT, PROVIDE 4 X 4 BOX AND 1" CONDUIT
FROM BOX TO SERVER ROOM, COORDINATE CONDUIT STUBUP
LOCATION WITH RELATIVITY. JACK AND CABLE BY OTHERS. |

17. THE CONTRACTOR SHALL PROVIDE AND KEEP UP TO DATE A COMPLETE RECORD SET OF CONSTRUCTION "AS-BUILT'S" BLUELINE PRINTS WHICH SHALL BE CORRECTED DAILY, AND SHALL SHOW EVERY CHANGE FROM THE ORIGINAL CONTRACT DRAWINGS, INCLUDING ADDENDA AND CHANGE ORDERS IN ACCORDANCE WITH GENERAL REQUIREMENTS AND SPECIAL CONDITIONS. THIS SET OF PRINTS SHALL BE KEPT ON THE JOB SITE, AND SHALL BE USED ONLY AS A RECORD SET. THIS SHALL NOT BE CONSTRUED AS AUTHORIZATION FOR THE CONTRACTORS TO MAKE CHANGES IN THE LAYOUT WITHOUT DEFINITE INSTRUCTION IN EACH CASE.

1. THE CONTRACTOR SHALL KEEP THE CONSTRUCTION SITE CLEAN OF ALL WASTE MATERIALS AND RUBBISH CAUSED BY HIS WORK OR EMPLOYEES. UPON COMPLETION OF THE WORK AND AT TIMES DURING PROGRESS OF THE WORK WHEN REQUESTED BY THE GOVERNMENT, THE CONTRACTOR SHALL REMOVE ALL SURPLUS MATERIALS, RUBBISH, AND DEBRIS RESULTING FROM THE OPERATION, AND SHALL LEAVE THE ENTIRE BUILDING AND INVOLVED PORTIONS OF THE SITE, INsofar AS THE WORK OF THE CONTRACT IS CONCERNED, IN A NEAT, CLEAN, AND ACCEPTABLE CONDITION AS APPROVED BY THE GOVERNMENT. EQUIPMENT, LIGHTING FIXTURES, MATERIALS AND ACCESSORIES SHALL BE THOROUGHLY CLEANED OF CEMENT, PLASTER, AND OTHER MATERIALS.
2. THE CONTRACTOR SHALL PROVIDE ADEQUATE PROTECTION, WHEREVER WORK IS TO BE PERFORMED IN FINISHED/OCCUPIED SPACES, TO PREVENT DAMAGE TO ADJACENT AREAS, EQUIPMENT, OR FURNISHINGS; TO PREVENT ACCIDENTAL INJURY TO BUILDING OCCUPANTS AND THE PUBLIC; TO PREVENT THE SPREADING OF DUST, DIRT, DEBRIS, AND MOISTURE FROM THE AREA WHERE WORK IS BEING PERFORMED; AND TO PREVENT STUNT, DIRT, DEBRIS, AND MOISTURE FROM GETTING ON OR IN THE BUILDING OCCUPANTS FURNISHINGS OR EQUIPMENT.
3. THE CONTRACTOR SHALL REPAIR, AT NO COST TO THE GOVERNMENT, ANY DAMAGE DONE BY HIMSELF OR HIS EMPLOYEES. HE SHALL ALSO BE RESPONSIBLE FOR ALL CUTTING AND PATCHING REQUIRED TO PROPERLY INSTALL HIS WORK.

ALL DRAWINGS ARE SCHEMATIC. EXACT LOCATIONS SHALL BE DETERMINED BY THE CONSTRUCTION AND STRUCTURE OF THE BUILDING AND SHALL BE VERIFIED AND COORDINATED IN THE FIELD. ANY INSTALLATION OR CONSTRUCTION CONFLICTS WHICH OCCUR IN THE FIELD SHALL BE RESOLVED BY THE TRADE CONTRACTOR TO THE SATISFACTION OF THE OWNER AND ARCHITECT AND AT NO EXPENSE TO THE OWNER, ARCHITECT AND/OR ENGINEER.

1. ALL APPLICABLE PORTIONS OF AFI 32-1065, AFMAN 91-201, UFC 3-575-01
2. NFPA 70 - 2020 EDITION

REVISIONS		
NO.	DATE	DESCRIPTION
1		
2		
3		
4		
5		
6		
7		
8		
9		

ELECTRICAL DESIGN VARIOUS FACILITIES

STENNIS SPACE CENTER
MS 39529

JOB # RS - 22.02

DRAWN: MP

APPROVED: MP

DATE:	4.28.2022
-------	-----------

ELECTRICAL SPECIFICATIONS

E-001

MICHAEL PILO
FL P.E. # 50067

SIGNATURE

DATE _____

FE
PILO ENGINEERING
540 HIBISCUS BLVD
MEERBUTT ISLAND, FL 32952
(321) 427-3644
MPE-PILOENG@TEL-RR.COM
H4W4PILOENG@INVERJON.COM
FL C.A. # 26294

MICHAEL PILO, PE
FL P.E. # 50867

CONSULTANTS:

REVISIONS		
NO.	DATE	DESCRIPTION
1		
2		
3		
4		
5		
6		
7		
8		
9		

PROJECT

RELATIVITY SPACE

ELECTRICAL DESIGN
VARIOUS FACILITIES

LOCATION

TENNIS SPACE CENTER
MS 39529

DB # RS - 22.02

RAWN:	MP
-------	----

APPROVED:	MP
-----------	----

DATE:	4.28.2022
-------	-----------

DRAWING TITLE

ELECTRICAL KEY PLAN


DRAWING

E-100

MICHAEL PILO
P.E. # 50067

SIGNATURE


ATE

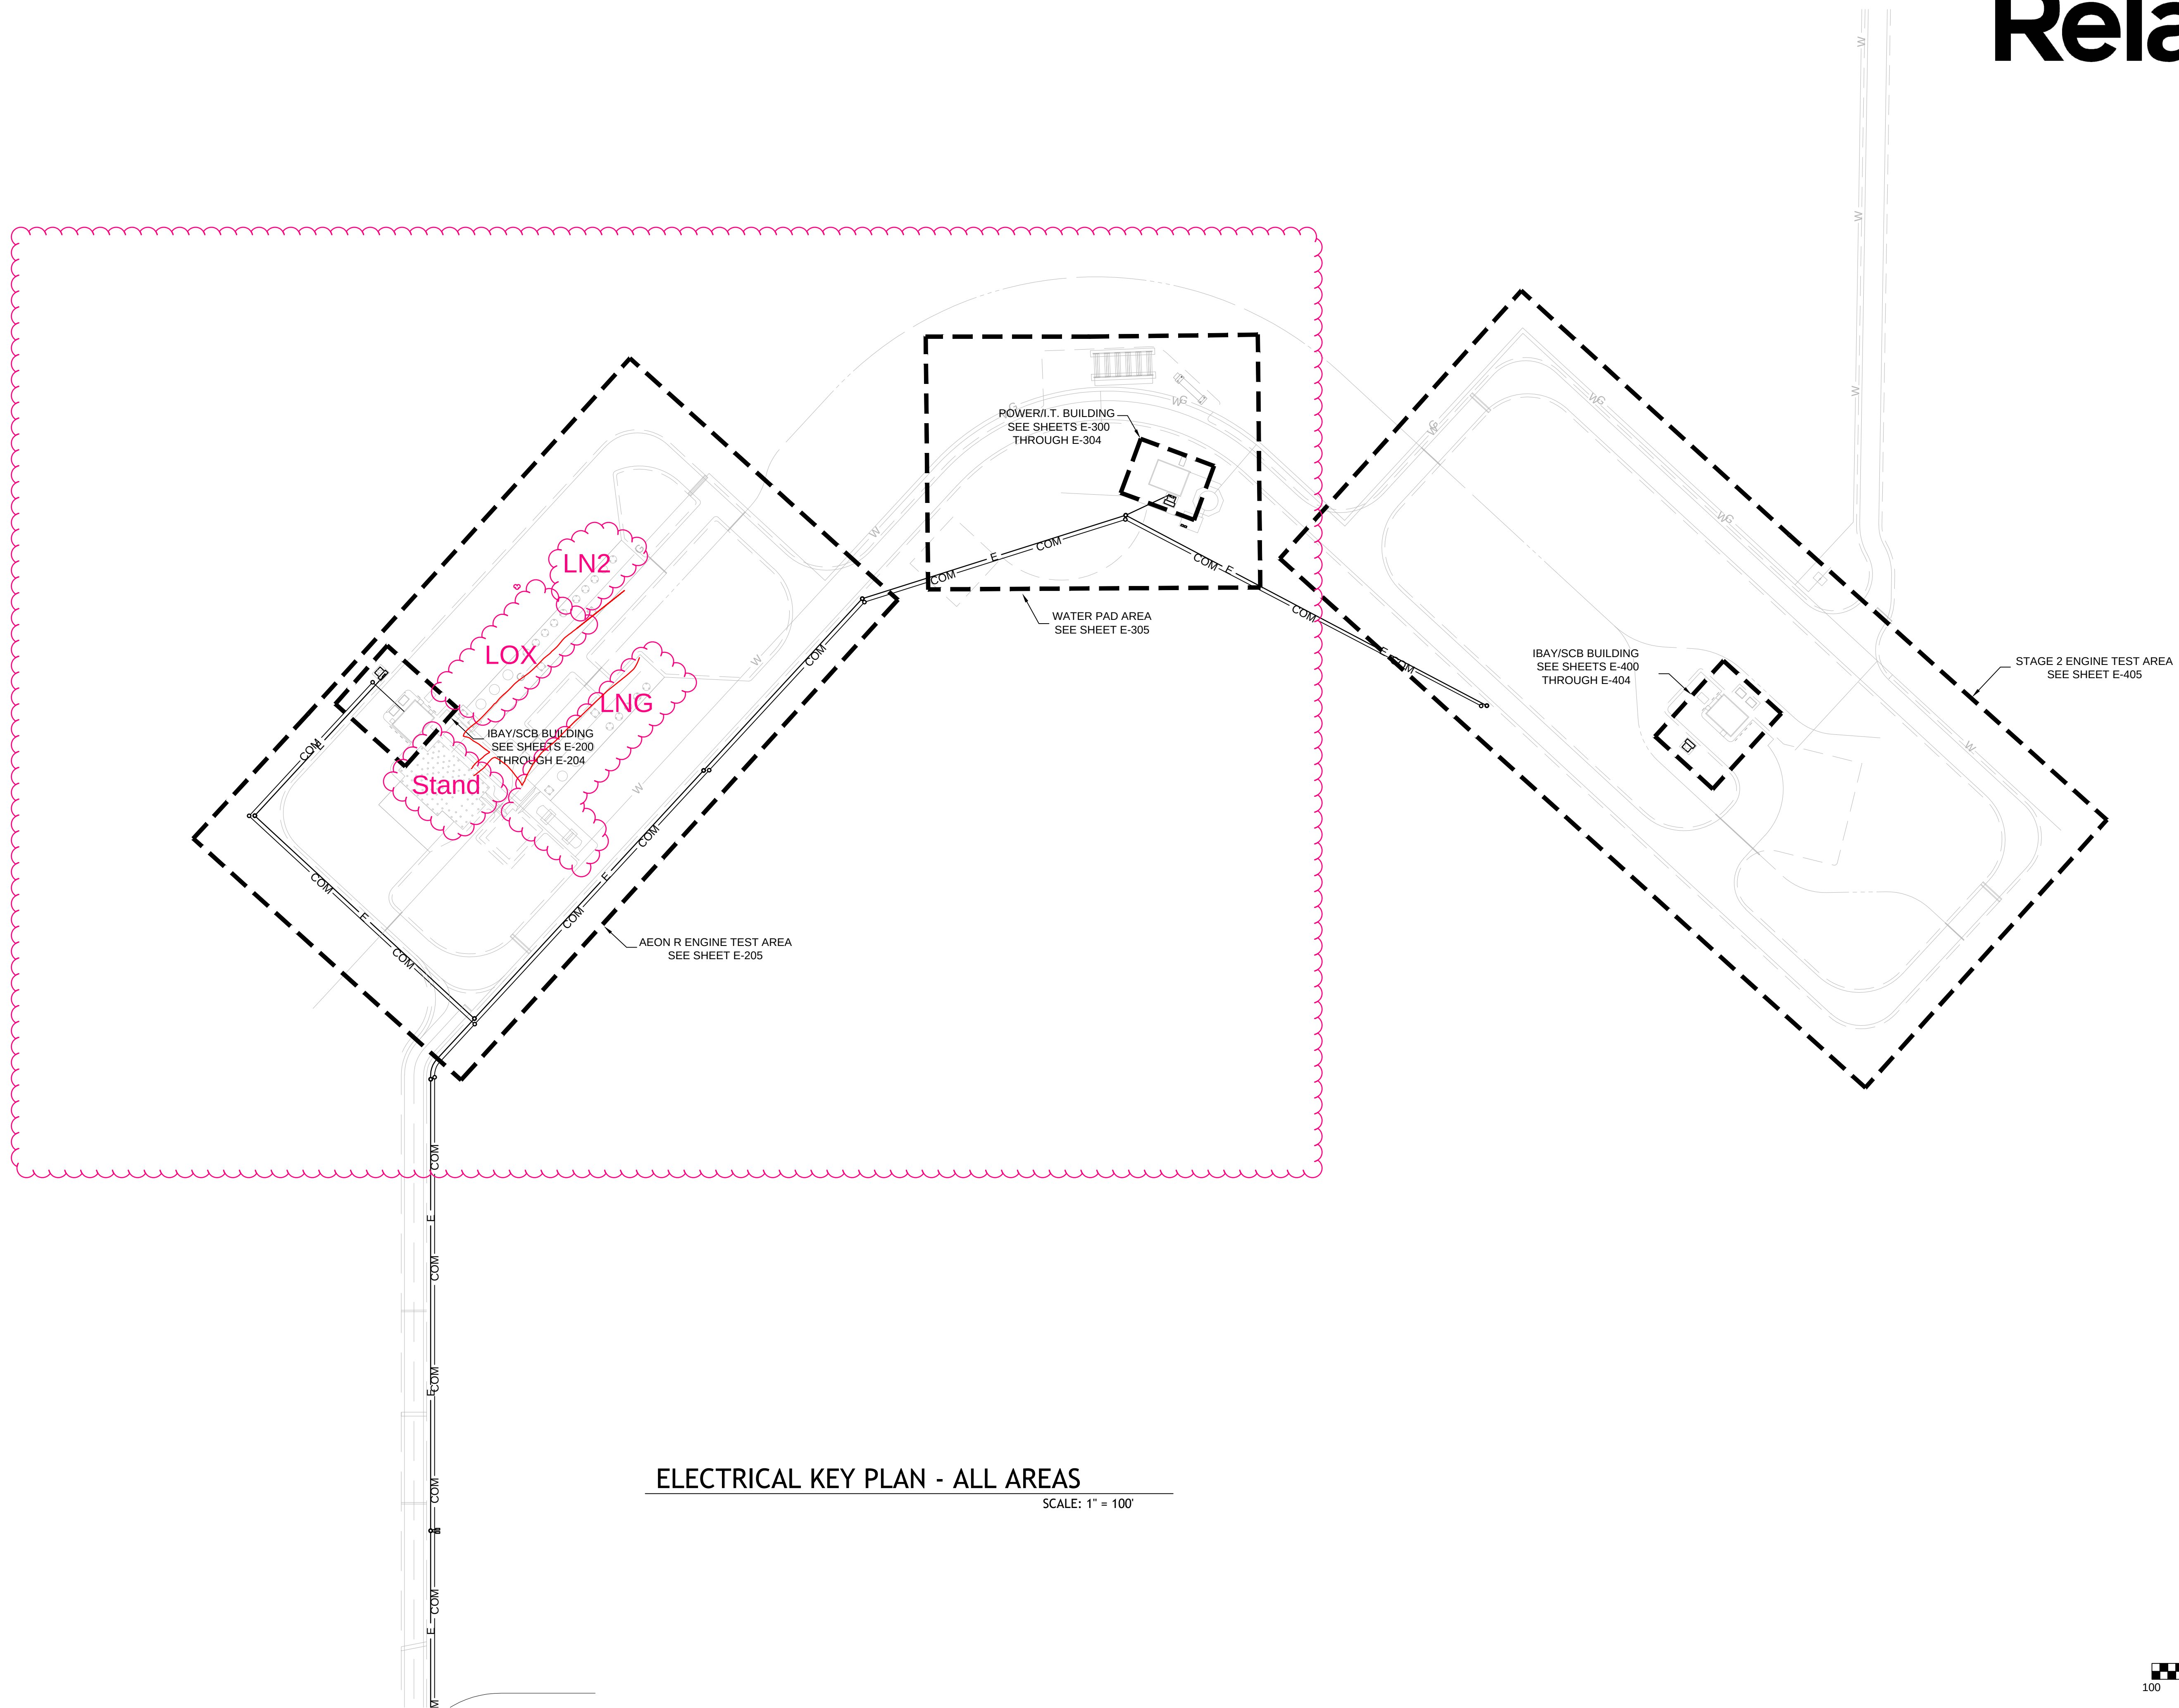

ELECTRICAL KEY PLAN - ALL AREAS

SCALE: 1" = 100'

 HORIZONTAL SCALE: 1" = 100'





2. ALL CONDUCTORS SHALL BE COPPER THWN UNLESS OTHERWISE NOTED.

3. GROUNDING SYSTEM SHALL COMPLY WITH NEC 250, SEE DIAGRAM ON E-5.0

Fault currents are calculated under the assumption of a 750 kVA utility transformer with 5.75% impedance.

FEEDER CABLES HAVE GREEN UP COVERS APPLICABLE FOR A MAXIMUM 50 VOLTAGE DROP FROM SERVICE TRANSFORMER TO CONNECTED EQUIPMENT.

METER CABINET AND METER BY RELATIVITY.


PROVIDE ARC FLASH CLAD, ON MSSB AND PANELBOARDS IN ACCORDANCE WITH NEC 110.16.

PROVIDE AVAILABLE FAULT CURRENT DATA, ON MAIN IN ACCORDANCE WITH NEC 110.24.

PROVIDE COMPRESSION LUGS FOR THE FOLLOWING PANEL/SWITCHBOARD INPUTS:

ETS-M5B
ETS-GEN-H1
ETS-STAND-H1
ETS-LOW-H1
ETS-LN1-H1
ETS-LN2-H1

PROVIDE COMPRESSION LUGS FOR ALL TRANSFORMER CONNECTIONS.

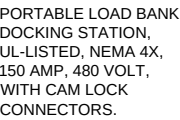PROJECT

LOCATION

STENNIS SPACE CENTER
MS 39529

JOB # RS - 22.02

DRAWN: MP

APPROVED:	MP
DATE:	4.28.2022

DRAWING TITLE

SINGLE LINE DIAGRAM
AEON R ENGINE AREA

DRAWING

E-200

MICHAEL PILO
FL P.E. # 50067

SIGNATURE

DATE _____

CONSULTANTS:

REVISIONS		
NO.	DATE	DESCRIPTION
1		
2		
3		
4		
5		
6		
7		
8		
9		

PROJECT	
RELATIVITY SPACE	
ELECTRICAL DESIGN VARIOUS FACILITIES	
LOCATION	
STENNIS SPACE CENTER MS 39529	
JOB #	RS - 22.02
DRAWN:	MP
APPROVED:	MP
DATE:	4.28.2022


DRAWING TITLE
IBAY/SCB BUILDING ELECTRICAL EQ. PLAN AEON R ENGINE AREA

DRAWING
E-201

MICHAEL PILO FL P.E. # 50067
SIGNATURE
DATE

PLAN NOTES

- SERVICE TRANSFORMER.
- MAIN SWITCHBOARD ETS-MSB.
- GENERATOR PANEL ETS-GEN-H1 (480/277V).
- UPS PANEL ETS-UPS-H1 (480/277V).
- UPS PANEL ETS-UPS-L1 (120/208V).
- UPS PANEL ETS-UPS-L2 (120/208V)
- GEN PANEL ETS-GEN-L1 (120/208V).
- GEN PANEL ETS-GEN-L2 (120/208V) - ACTUAL LOCATION TO BE DETERMINED.
- TRANSFORMERS ETS-UPS-TX1 AND ETS-UPS-TX2 (STACKED)
- TRANSFORMERS ETS-GEN-TX1 AND ETS-GEN-TX2 (STACKED)
- GENERATOR DOCKING STATION
- AUTOMATIC TRANSFER SWITCH ETS-ATS1
- MANUAL TRANSFER SWITCH ETS-MTS-1
- ETS-UPS
- UPS BATTERY CABINET
- UPS MBS
- PROVIDE FREE-STANDING CHANNEL FRAME TO SUPPORT PANELBOARDS, FRAME SHALL BE STRUCTURALLY FASTENED TO FLOOR AND DECK. EXACT LOCATION OF FRAME SHALL ALLOW FOR MINIMUM REQUIRED CLEARANCES IN FRONT OF ELECTRICAL EQUIPMENT.
- UNDERGROUND SERVICE CONSISTING OF THWN CONDUCTORS IN DIRECT-BURIED SCHEDULE-40 PVC CONDUIT WITH 24" COVER MINIMUM.
- TRANSFORMER DISCONNECT.
- LIGHTING CONTROL PANEL
- UPS LOAD BANK DOCKING STATION
- APPROXIMATE LOCATION OF PERMANENT GENERATOR
- UNDERGROUND GENERATOR FEEDER CONSISTING OF THWN CONDUCTORS IN DIRECT-BURIED SCHEDULE-40 PVC CONDUIT WITH 24" COVER MINIMUM
- INSTALL 48" X 6" CABLE TRAY ABOVE COMM RACKS AS SHOWN, TRAY SHALL BE SUSPENDED ABOVE RACKS, COORDINATE ELEVATION WITH RELATIVITY. COORDINATE TRAY TYPE & MATERIAL WITH RELATIVITY.
- INSTALL 36" X 6" CABLE TRAY ON WALL, FROM 36" AFG TO ELEVATION TBD. COORDINATE TRAY TYPE & MATERIAL WITH RELATIVITY.
- PROVIDE TWO SHEETS OF FIRE RATED PLYWOOD, 4' X 8' X 3/4" AND INSTALL SIDE-TO-SIDE DIRECTLY ON WALL. PROVIDE DEDICATED RECEPTACLES FOR ACCESS CONTROL SYSTEM AND HVAC CONTROL SYSTEM.
- COORDINATE EXACT LOCATION AND ELEVATION OF MELTRIC RECEPTACLES ABOVE RACKS.
- PROPOSED LOCATION OF GENERATOR REMOTE ANNUNCIATOR.
- PROPOSED LOCATION OF CONDUIT STUBUPS FOR CAMERA POWER (5 X 2"), GATE POWER (1 X 2"), AND FLARE STACK POWER (2 X 1").
- 3 X 4" CONDUIT STUBUPS FROM COMM DUCTBANK.
- 7 X 2" CONDUIT STUBUPS FOR CAMERA DAQ (5 EA), FLARE STACK DAQ (1 EA), AND GATE NETWORK (1 EA)
- 5 X 1" CONDUIT STUBUPS FOR CAMERA NETWORK.
- EXTEND TWO 4-IN-1 INNER DUCTS, CONTAINING 144 STRANDS AND 24 STRANDS, FROM 4" CONDUITS TO RACKS.
- PROVIDE FLUSH BOX FOR CARD READER, WITH 3/4" CONDUIT TO LOCATION TBD BY OWNER.

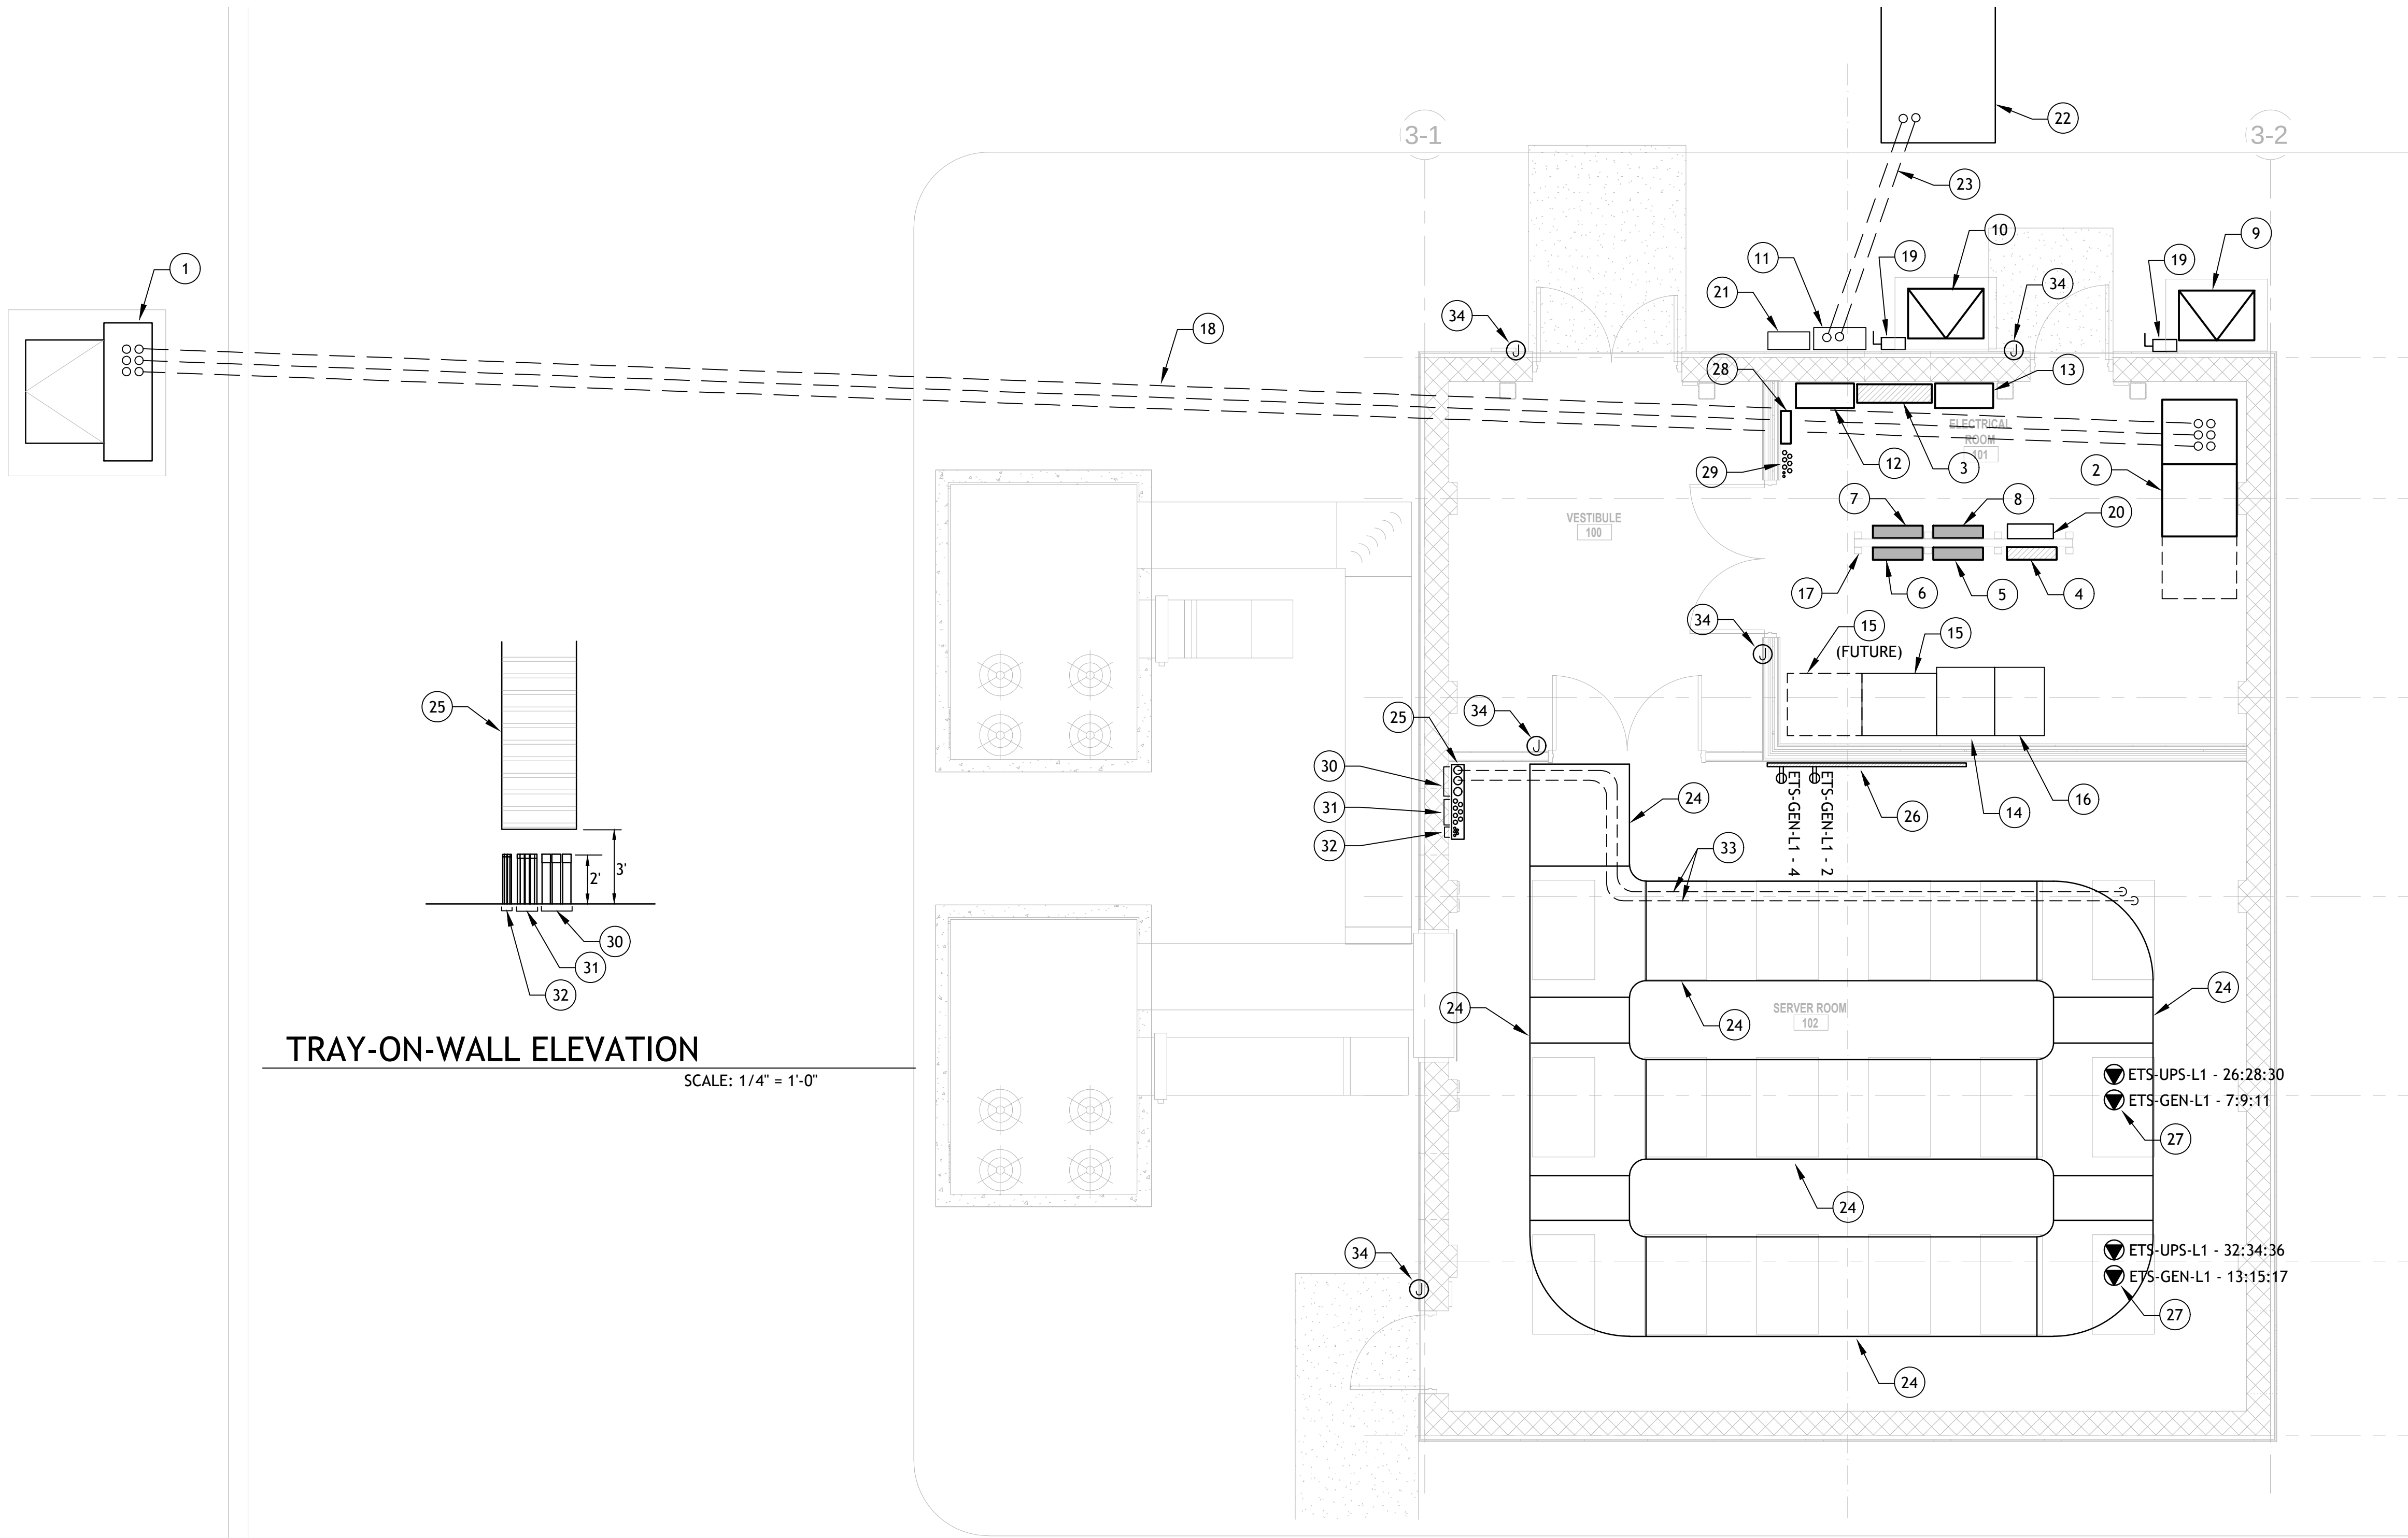

TRAY-ON-WALL ELEVATION

SCALE: 1/4" = 1'-0"

IBAY/SCB BUILDING ELECTRICAL EQUIPMENT PLAN - AEON R ENGINE AREA

SCALE: 1/4" = 1'-0"

CONSULTANTS:


REVISIONS		
NO.	DATE	DESCRIPTION
1		
2		
3		
4		
5		
6		
7		
8		
9		

PROJECT	
RELATIVITY SPACE	
ELECTRICAL DESIGN VARIOUS FACILITIES	
LOCATION	
STENNIS SPACE CENTER MS 39529	
JOB #	RS - 22.02
DRAWN:	MP
APPROVED:	MP
DATE:	4.28.2022

DRAWING TITLE
IBAY/SCB BUILDING ELECTR/LIGHTING PLAN AEON R ENGINE AREA

DRAWING
E-202

MICHAEL PILO FL P.E. # 50067
SIGNATURE
DATE

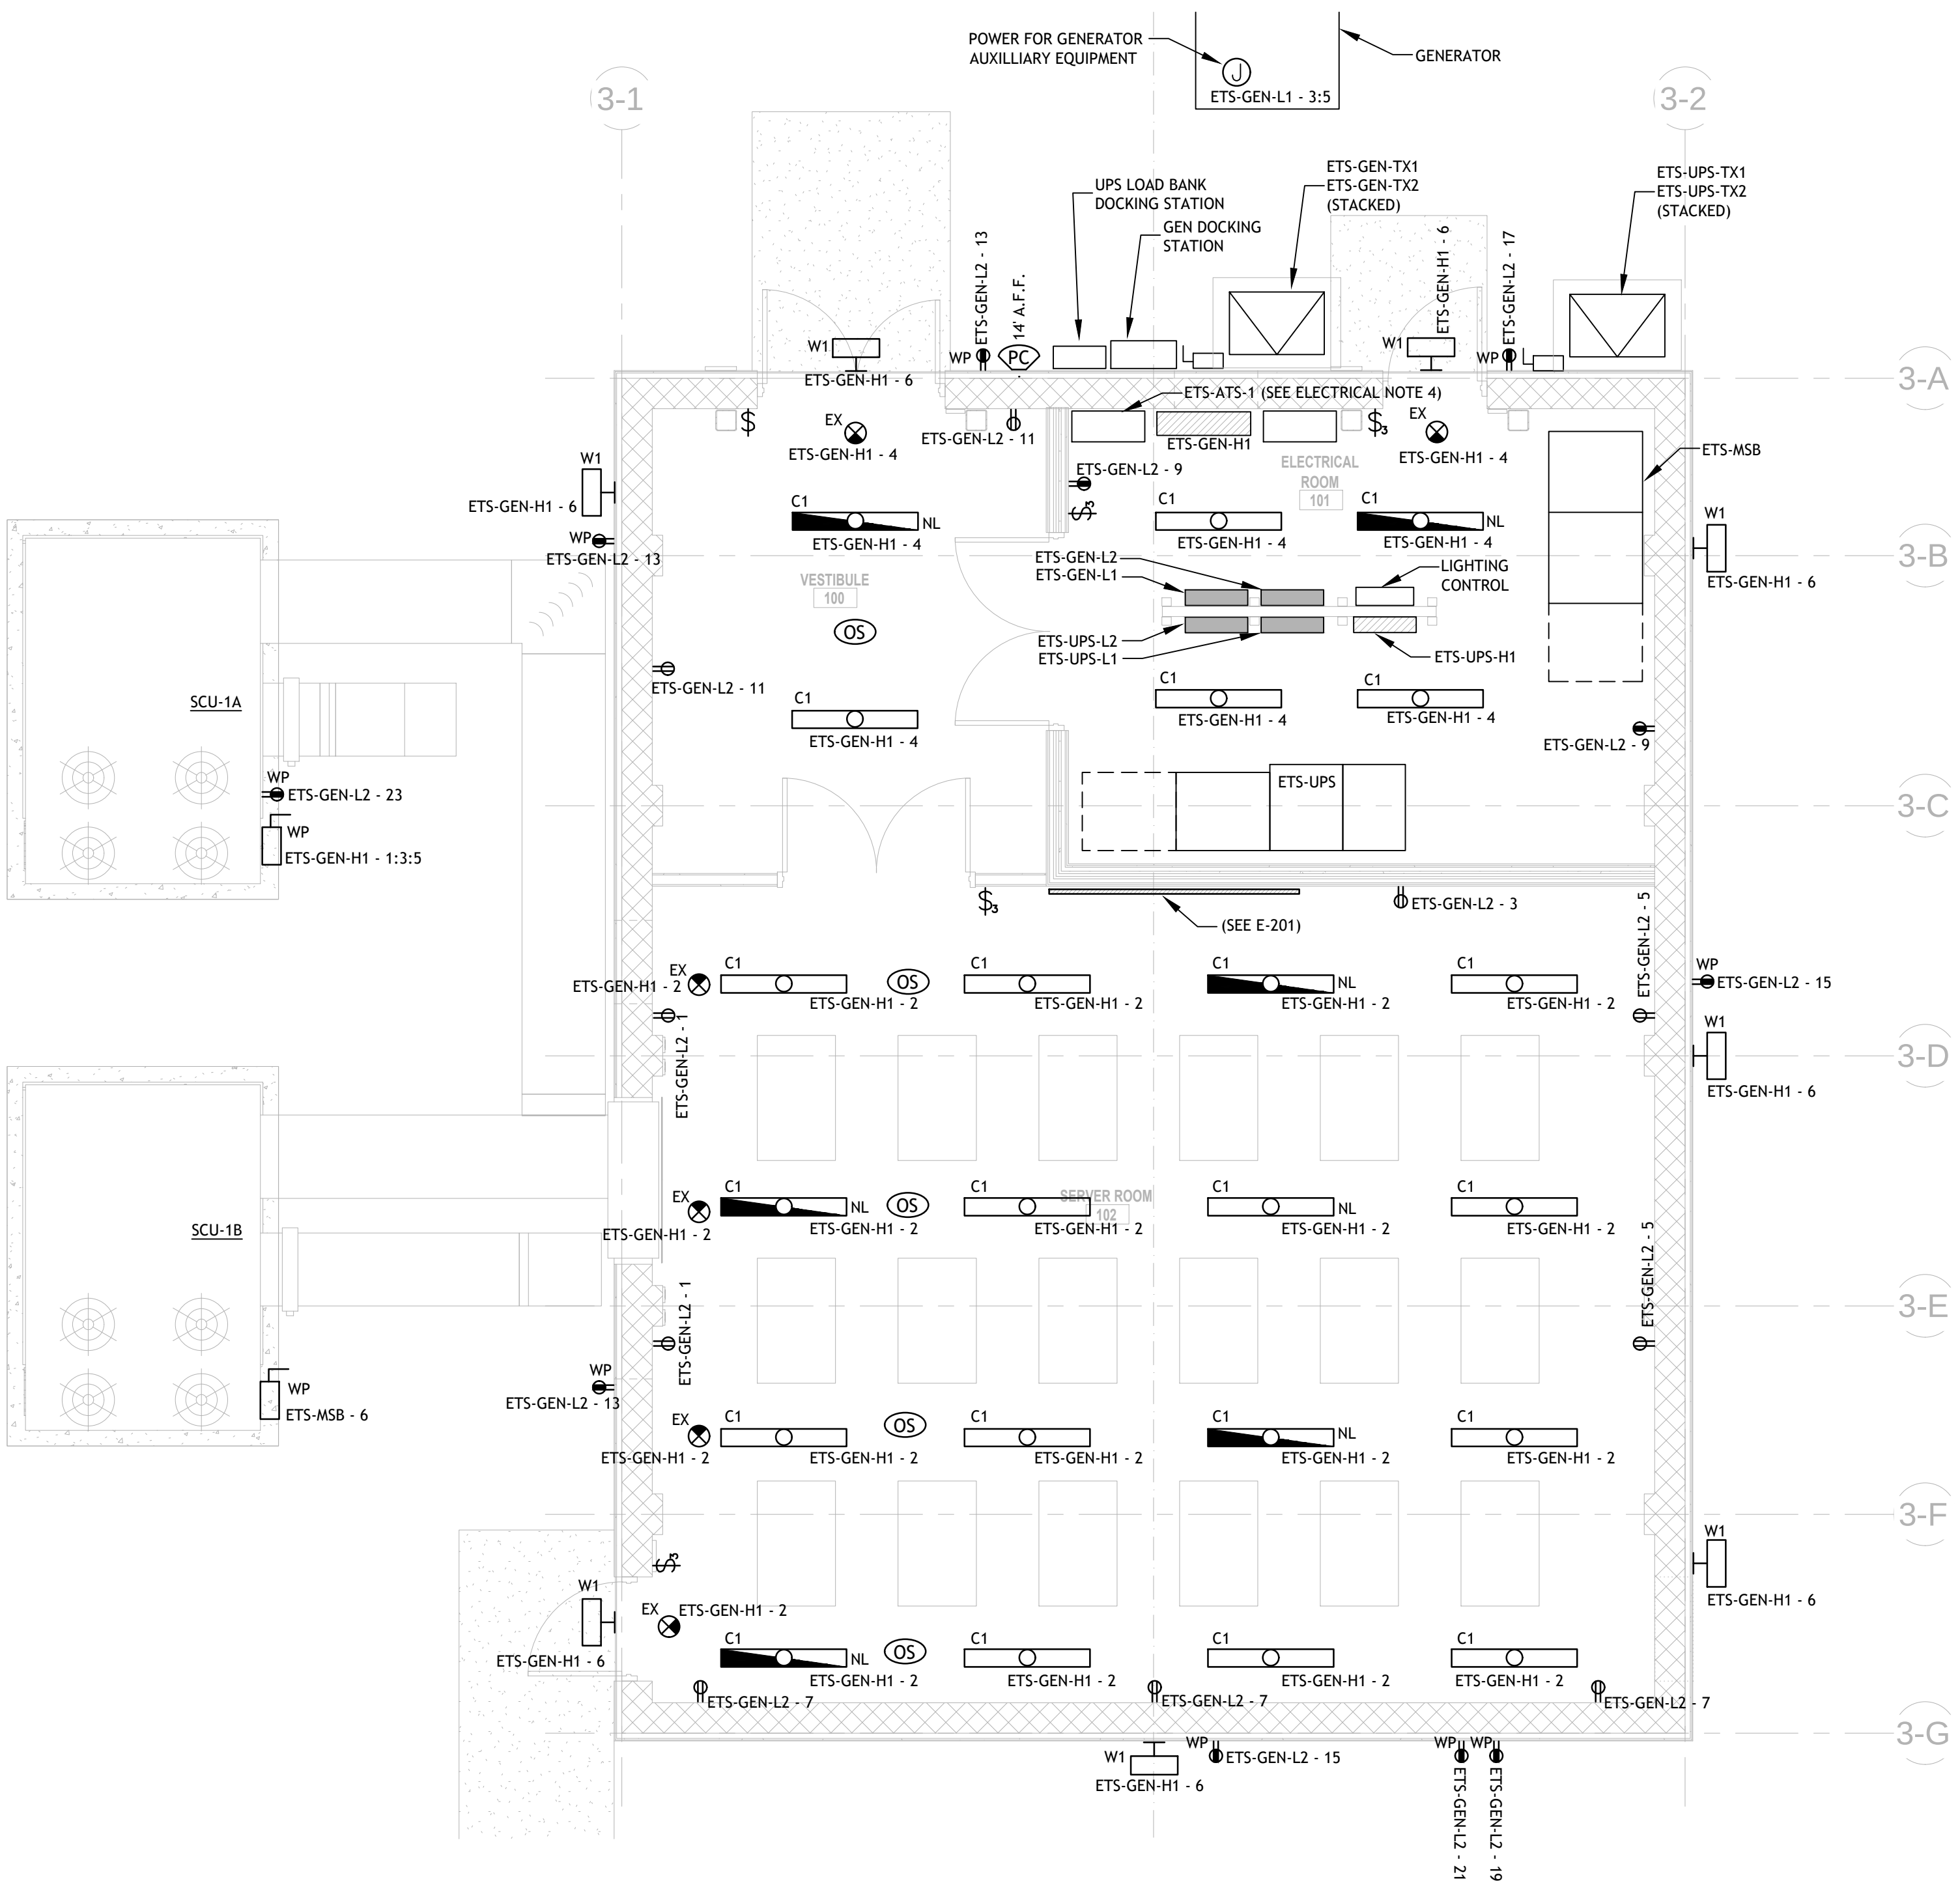

LIGHTING NOTES


- EXIT AND EMERGENCY LIGHTS SHALL BE CONNECTED TO THE UNSWITCHED SIDE OF LIGHT CIRCUIT.
- INTERIOR LIGHTING SHALL BE CONTROLLED THROUGH ARP LIGHTING CONTROL PANEL WITH LOW VOLTAGE WALL SWITCHES AND VACANCY SENSORS (WHERE SHOWN). EXTERIOR LIGHTING SHALL BE CONTROLLED WITH ARP LIGHTING CONTROL PANEL AND ONE LOW VOLTAGE WALL SWITCH LOCATED IN ELECTRICAL ROOM.
- ALL LIGHTING FIXTURES SHALL BE SERVED BY PANEL AND CIRCUIT NUMBER INDICATED.
- HALF-SHADED FIXTURES SHALL CONTAIN EMERGENCY LIGHT BATTERY BACKUP.

LIGHTING FIXTURE SCHEDULE					
#	TYPE	MANUFACTURER / PART #	LAMP	LUMENS	W
C1	LINEAR SUSPENDED LED, 4', WITH STEM	LITHONIA / BLWP4-60L-ADSM-LP840	LED	6,000	60
W1	WALL MOUNTED EXTERIOR, CUTOFF	LITHONIA / DSXW1-LED-20C-350- 50K- T35	LED	3,000	34
EX	EXIT LIGHT WITH BATTERY BACKUP	LITHONIA	LED	-	5

FIXTURE SELECTION REPRESENT BASIS OF DESIGN, EQUAL SUBSTITUTES ARE ACCEPTABLE.

ELECTRICAL NOTES

- ALL EQUIPMENT AND DEVICES SHALL BE FED FROM PANELS AND CIRCUITS INDICATED, SEE E-201 FOR PANEL LOCATION. SEE PANEL SCHEDULES, E-204
- PROVIDE DISCONNECTS, STARTERS, FEEDERS, AND CONNECTIONS FOR NEW DEVICES, AND HVAC EQUIPMENT AS SHOWN. ALL EQUIPMENT LOCATED OUTSIDE SHALL BE WEATHERPROOF, WIRING METHODS SHALL BE SUITABLE FOR WET LOCATIONS.
- FOR GENERATOR AND ETS-ATS-1 PROVIDE THE FOLLOWING ITEMS:
GENERATOR TO NETWORK ROOM - 1X 3/4" CONDUIT1- 1X CAT6 CABLE
GENERATOR TO ATS - 2X 3/4" CONDUITS1- 8X #12 AWG THHN2- 2X BELDEN #9842
GENERATOR TO REMOTE ANNUNCIATOR - 1X 3/4" CONDUIT1- 2X#12 AWG THHN & 1X BELDEN #9842 CABLE
GENERATOR TO ELECTRIC ROOM - 1X 3/4"-1- SPARE
GENERATOR TO ETS-GEN-L1 - 1X 1" CONDUIT1- GENERATOR 120V CIRCUIT
ATS TO NETWORK ROOM - 1X 3/4" CONDUIT1- 1X CAT6 CABLEATS TO GENERATOR DOCKING STATION (GDS) - 1X 1" CONDUIT1- 10X#12 AWG THHN
ATS TO UPS - 1X 3/4" CONDUIT1-1X BELDEN #9842 CABLE
ATS POWER 1: 1X3/4" CONDUIT1- ATS 120V CIRCUIT ETS-GEN-L1 - 1
ATS POWER 2: 1X3/4" CONDUIT1- ATS 120V CIRCUIT ETS-UPS-L1 - 25
GEN AUX POWER: 1X1" CONDUIT - CIRCUIT ETS-GEN-L1 - 3:5

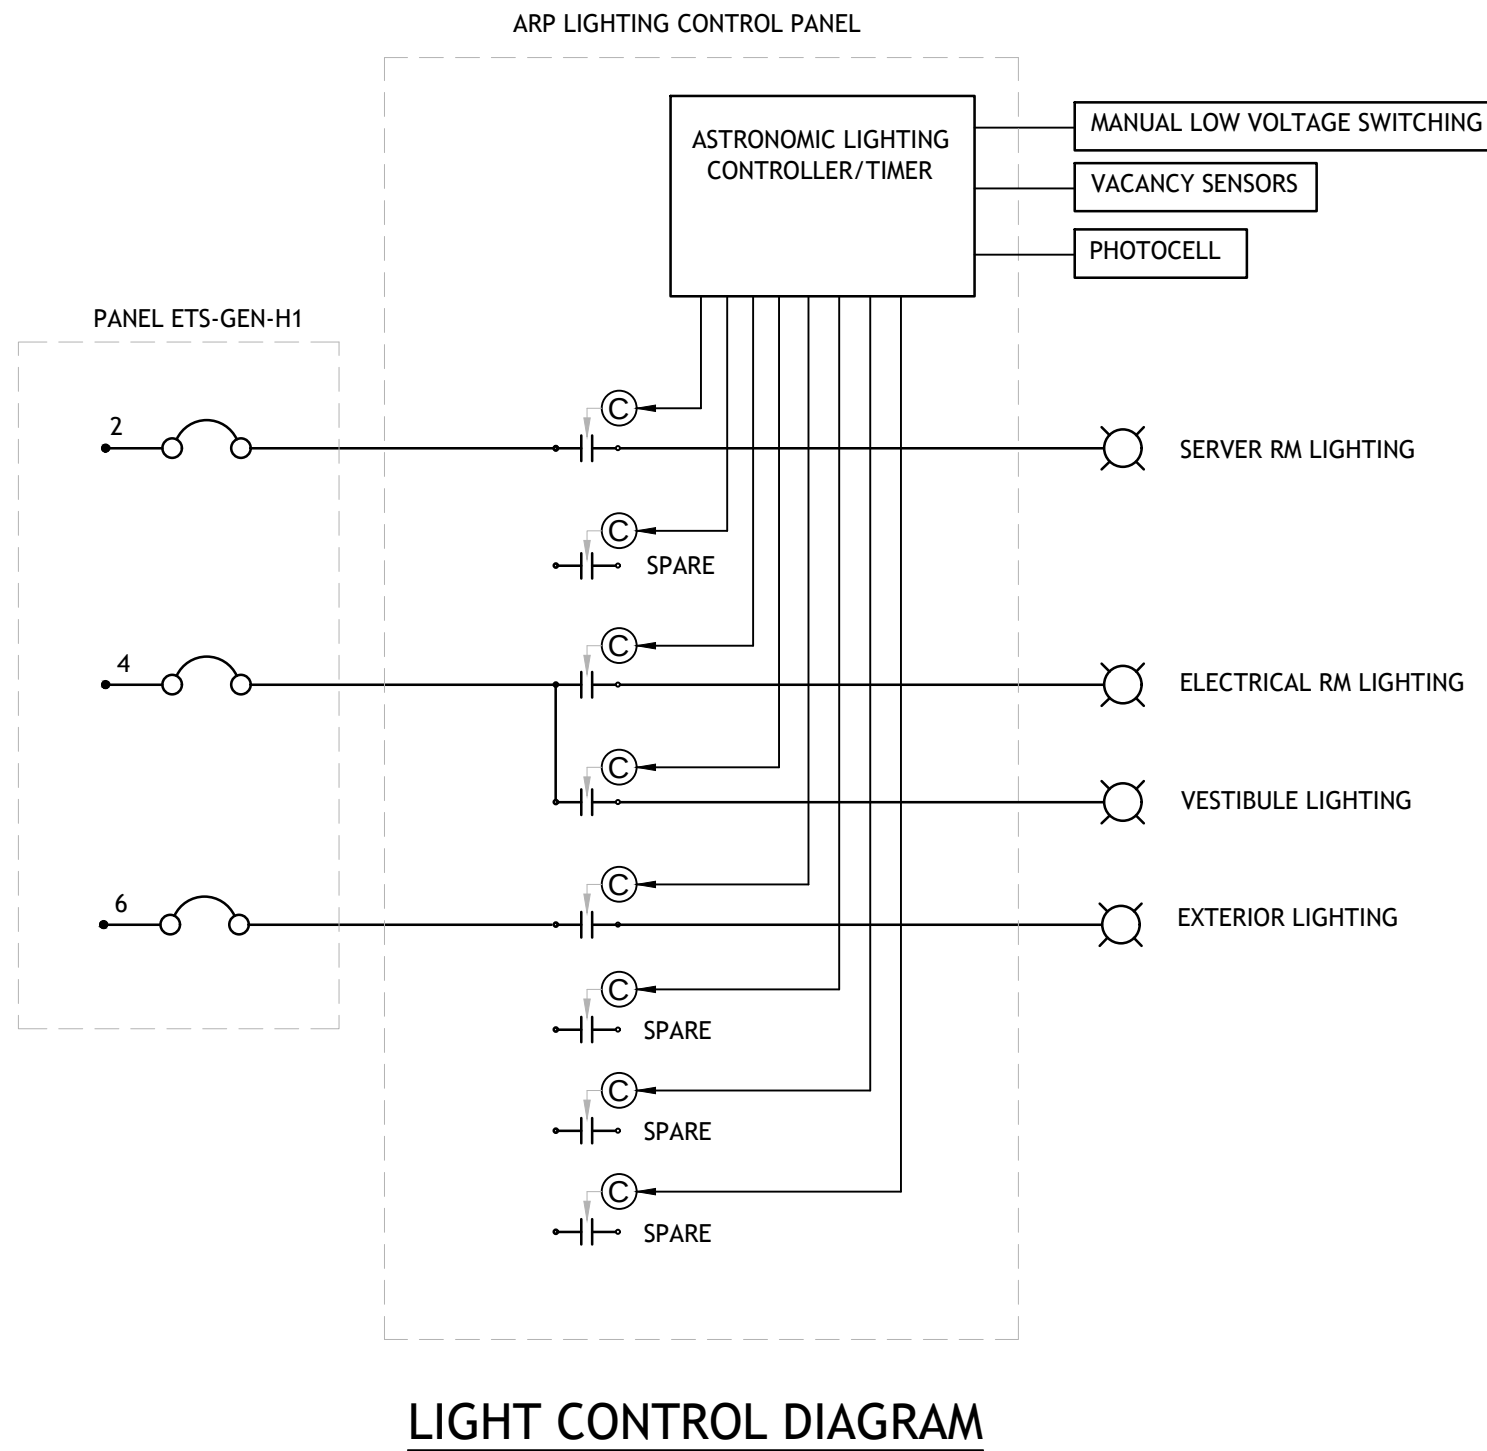

IBAY/SCB BUILDING ELECTRICAL AND LIGHTING PLAN - AEON R ENGINE AREA

SCALE: 1/4" = 1'-0"

Relativity

FE
PILO ENGINEERING
540 HIBISCUS BLVD
MERRITT ISLAND, FL 32952
(321) 427-3644
MP-PILOENG@PILO-RR.COM
WWW.PILOENGINEERING.COM
FL C.E. # 26294

MICHAEL PILO, P.E.
FL P.E. # 50067


CONSULTANTS:

REVISIONS		
NO.	DATE	DESCRIPTION
1		
2		
3		
4		
5		
6		
7		
8		
9		

PROJECT	
RELATIVITY SPACE	
ELECTRICAL DESIGN VARIOUS FACILITIES	
LOCATION	
STENNIS SPACE CENTER MS 39529	
JOB #	RS - 22.02
DRAWN:	MP
APPROVED:	MP
DATE:	4.28.2022


PLAN NOTES

1. PROVIDE AND INSTALL GROUND RING (COUNTERPOISE), TO CONSIST OF A SINGLE STRANDED #4/0 BARE COPPER CONDUCTOR, DIRECTLY BURIED 30" BELOW GRADE AND APPROXIMATELY 4' FROM EDGE OF FOUNDATION, AND PROVIDE GROUND RODS AS INDICATED. ALL CONNECTIONS TO COUNTERPOISE AND ALL JOINTS SHALL BE EXOTHERMICALLY WELDED, WITH THE EXCEPTION OF CONNECTION TO GROUND TEST WELL, WHICH SHALL BE MADE WITH MECHANICAL CONNECTORS.
2. GROUND ROD, 20' X 3/4"D, DRIVEN TO 12" BELOW GRADE. ALL CONNECTIONS TO GROUND ROD SHALL BE EXOTHERMICALLY WELDED.
3. GROUND WELL WITH GROUND ROD, 20' X 3/4"D, AND SLEEVE W/ COVER. ALL CONNECTIONS TO GROUND ROD SHALL BE UL-LISTED MECHANICAL CLAMPS.
4. PROVIDE #3/0 BARE STRANDED COPPER BOND FROM CONCRETE FOUNDATION STEEL TO GROUND RING. CONDUCTOR SHALL BE #3/0 BARE STRANDED COPPER.
5. INSTALL GROUND BUS COPPER BAR IN ELECTRICAL ROOM, 18" A.F.F. PROVIDE #3/0 BARE STRANDED COPPER BOND TO COUNTERPOISE AND TO BUILDING FOUNDATION STEEL AS INDICATED. CABLE CONNECTIONS TO BAR SHALL BE BOLT-ON MECHANICAL CRIMP CONNECTORS.
6. INSTALL GROUND BUS COPPER BAR IN SERVER ROOM, 18" A.F.F. PROVIDE #3/0 BARE STRANDED COPPER BOND TO COUNTERPOISE AND TO BUILDING FOUNDATION STEEL AS INDICATED. CABLE CONNECTIONS TO BAR SHALL BE BOLT-ON MECHANICAL CRIMP CONNECTORS.
7. PROVIDE CONNECTIONS TO EQUIPMENT AS INDICATED.
8. PROVIDE UNDERGROUND CABLE BOND FROM TRANSFORMER GROUND RING TO BUILDING GROUND RING. CONDUCTOR SHALL BE #4/0 BARE STRANDED COPPER, 30" BELOW GRADE.
9. PROVIDE UNDERGROUND CABLE BOND FROM GENERATOR GROUND RING TO BUILDING GROUND RING. CONDUCTOR SHALL BE #4/0 BARE STRANDED COPPER, 30" BELOW GRADE.

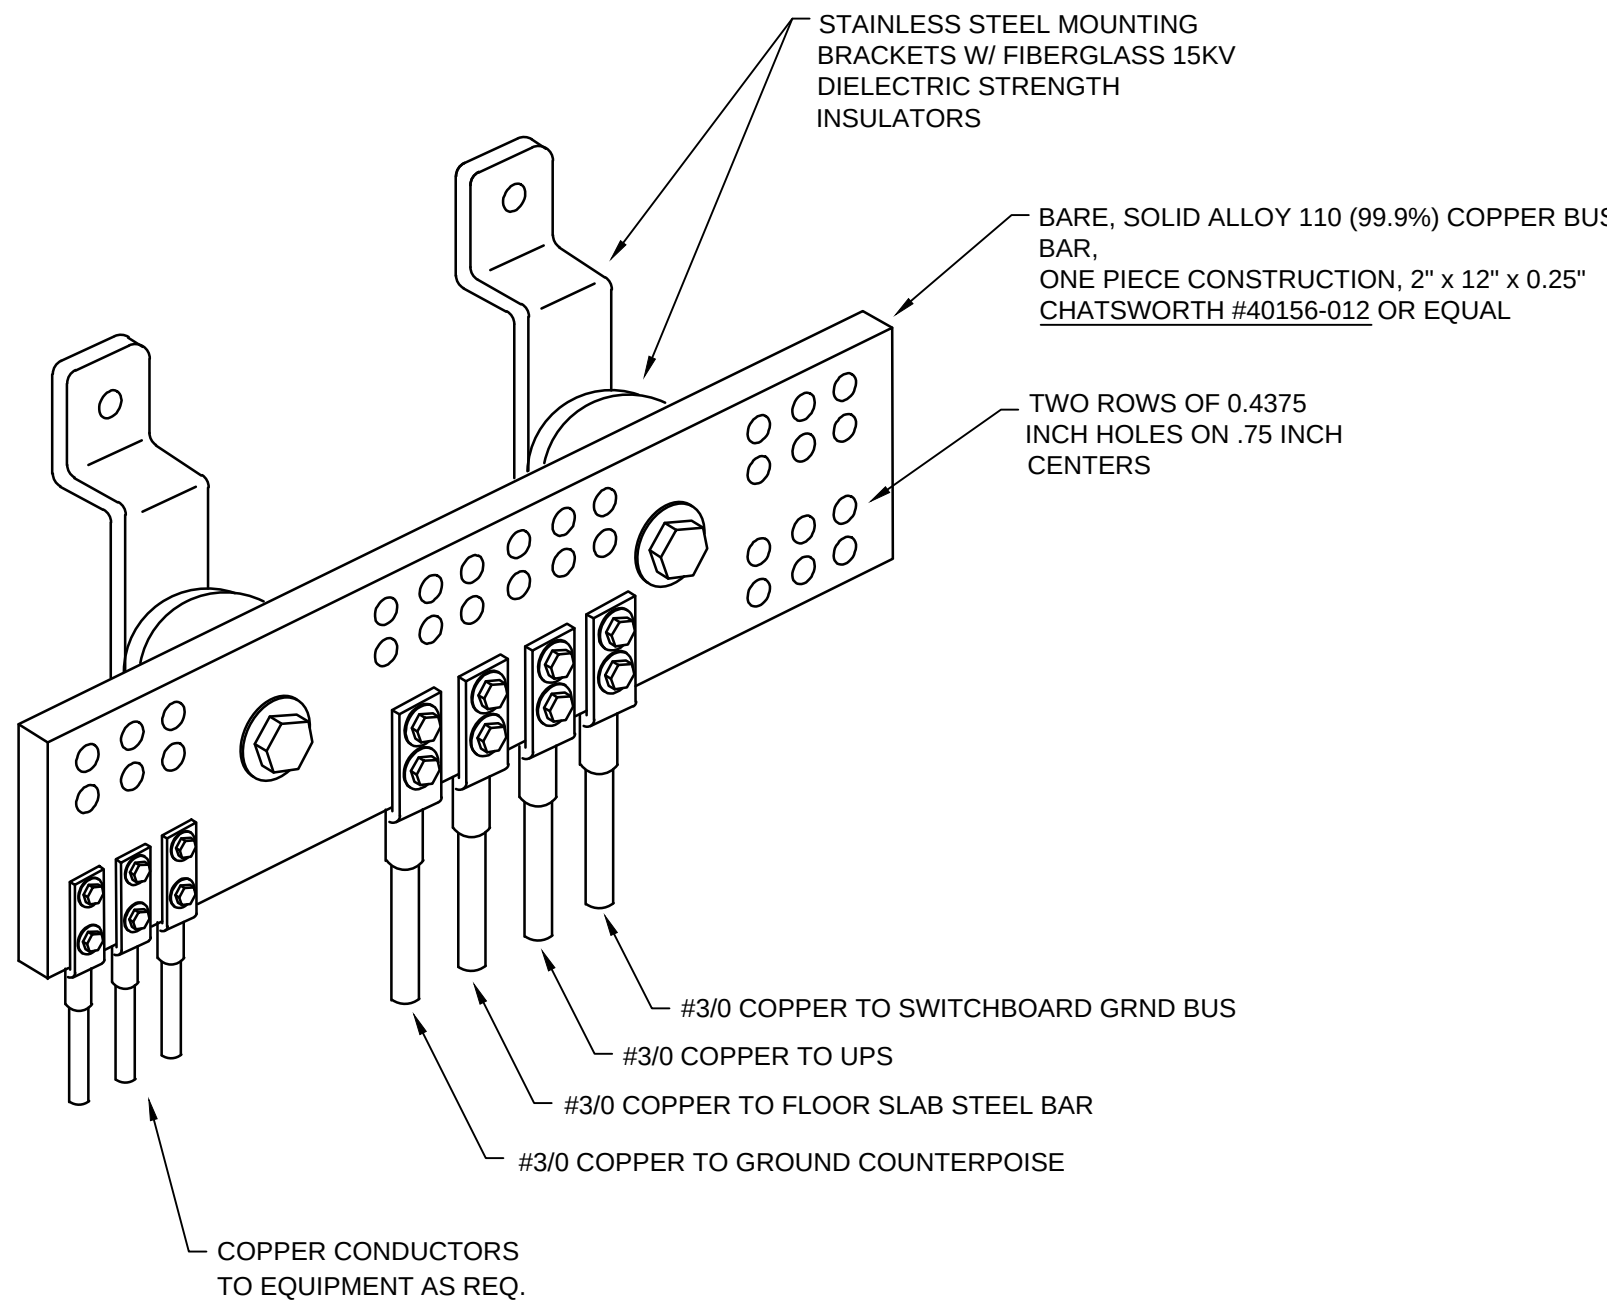

GROUND BUS BAR DETAIL


SCALE: NTS

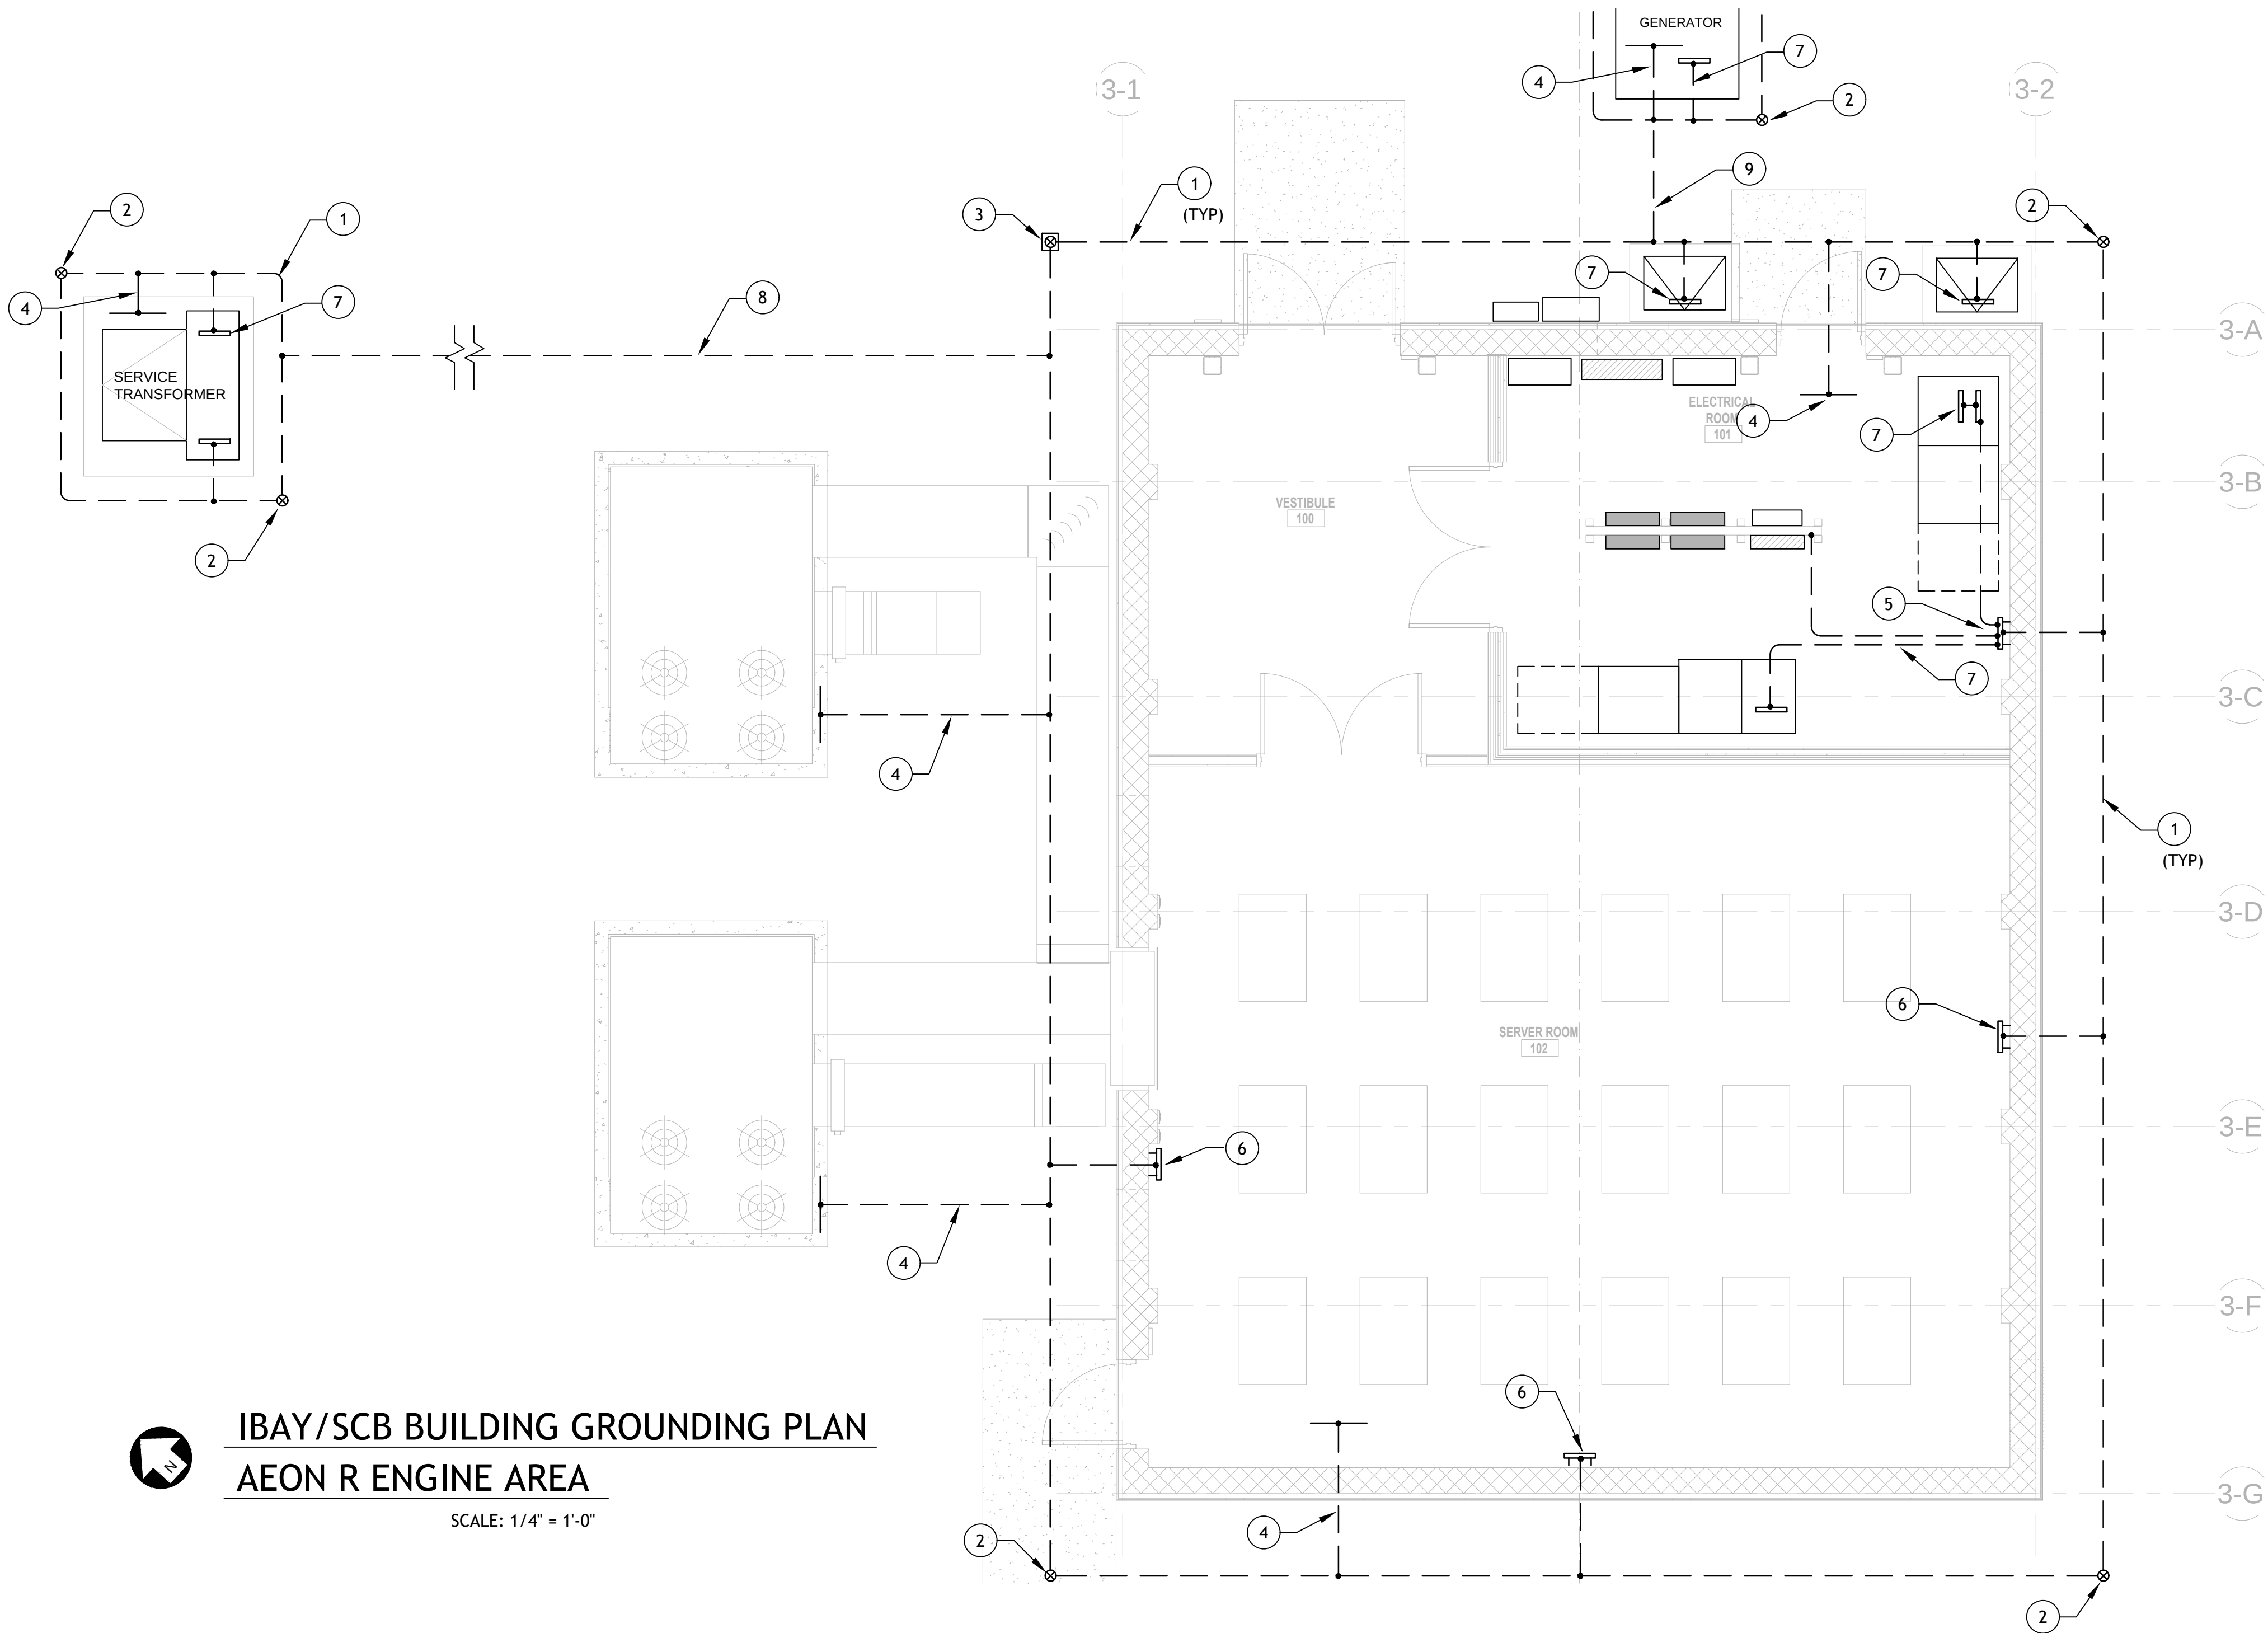

IBAY/SCB BUILDING GROUNDING PLAN

AEON R ENGINE AREA

SCALE: 1/4" = 1'-0"

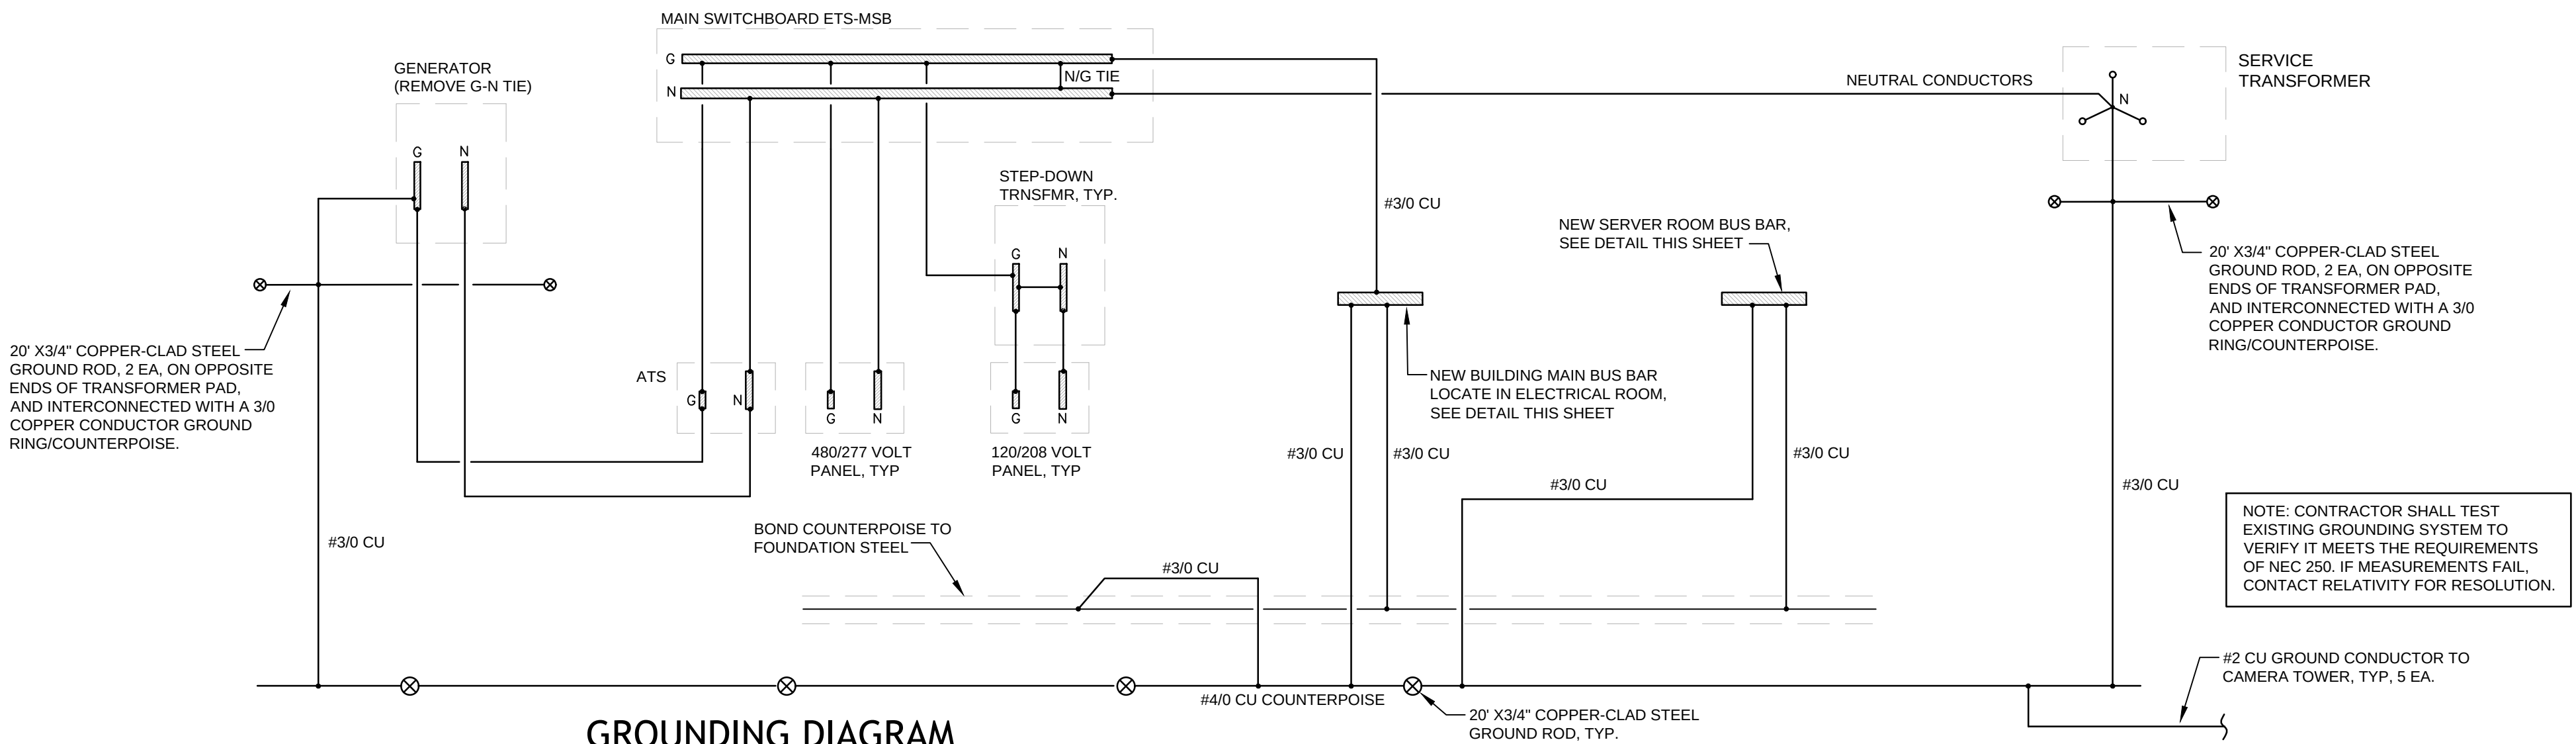

GROUNDING DIAGRAM

SCALE: NTS

DRAWING TITLE

IBAY/SCB BUILDING
GROUNDING PLAN
AEON R ENGINE AREA

DRAWING

E-203

MICHAEL PILO
FL P.E. # 50067

SIGNATURE

DATE

CONSULTANTS:

REVISIONS		
NO.	DATE	DESCRIPTION
1		
2		
3		
4		
5		
6		
7		
8		
9		

PROJECT		
RELATIVITY SPACE		
ELECTRICAL DESIGN VARIOUS FACILITIES		
LOCATION		
STENNIS SPACE CENTER MS 39529		
JOB # RS - 22.02		
DRAWN: MP		
APPROVED: MP		
DATE: 4.28.2022		

SWITCHBOARD: ETS-MSB															LUG LOCATION: BOTTOM															A.I.C.: \$5,000														
RATING: 2000 AMP MCB															SERVICE: 480/277 V, 3Ø, 4W															MOUNTING: SURFACE														
CKT. No.	EQUIPMENT SERVED	KVA			CKT. BRK.			BRANCH CIRCUIT			Ø	N	G	C	CKT. No.	EQUIPMENT SERVED	KVA			CKT. BRK.			BRANCH CIRCUIT																					
		A	B	C	P	TP.	Ø	N	G	C							A	B	C	P	TP.	Ø	N	G	C																			
1	SPD	-	-	-	3	60	*	*	*	*				2	FUTURE ETS-STND-H1				3	250	*	*	*	*																				
3	FUTURE ETS-LOX-H1				3	400	*	*	*	*				4	FUTURE ETS-LNG-H1				3	150	*	*	*	*																				
5	FUTURE ETS-LN2-H1				3	250	*	*	*	*				6	SCU-1B				3	70	*	*	*	*																				
7	ETS-GEN-TX2				3	45	*	*	*	*				8	UPS BYPASS				3	150	*	*	*	*																				
9	ETS-GEN-H1				3	400	*	*	*	*				10																														
11																																												
13																																												
15																																												
TOTAL		####	####	####											TOTAL		#####	#####	#####																									
EQUIPMENT SERVED					CONN. LOAD (KVA)					LF	DF	DESIGN LOAD					* SEE FEEDER SIZE ON SINGLE LINE DIAGRAM E-200																											
EQUIPMENT					#####					1	1.0	#####																																
					TOTAL (KVA)					#####																																		
					TOTAL (AMPS)					#####																																		

PANEL: ETS-GEN-H1															LUG LOCATION: TOP															A.I.C.: \$5,000														
RATING: 400 AMP MLO															SERVICE: 480/277V, 3Ø, 4W															MOUNTING: SURFACE														
CKT. NO.	EQUIPMENT SERVED	KVA	CKT. BKR.			BRANCH			CIRCUIT			#	Ø	N	GND	C	CT	EQUIPMENT SERVED	KVA	CKT. BKR.			#	Ø	N	GND	C	CT																
			A	B	C	P	TR.	A	B	C	A									B	C																							
1	SCU-1A					3		70	(SEE DIAG)								2	LIGHTING				1	20	10	10	10	3/4																	
3																	4	LIGHTING				1	20	10	10	10	3/4																	
5																	6	LIGHTING				1	20	10	10	10	3/4																	
7	ETS-GEN-TX1					3		100	(SEE DIAG)								8	SPARE				1	20																					
9																	10	SPARE				1	20																					
11																	12	SPARE				1	20																					
13	ETS-GEN-TX2	-				3		45	(SEE DIAG)								14	SPARE				1	20																					
15																	16	SPARE				1	20																					
17																	18	SPARE				1	20																					
19	ETS-UPS					3		150	(SEE DIAG)								20	SPARE				1	20																					
21																	22	SPARE				1	20																					
23																	24	SPARE				1	20																					
25	SPARE					1		20									26	SPARE				1	20																					
27	SPARE					1		20									28	SPARE				1	20																					
29	SPARE					1		20									30	SPARE				1	20																					
31	SPARE					1		20									32	SPARE				1	20																					
33	SPARE					1		20									34	SPARE				1	20																					
35	SPARE					1		20									36	SPARE				1	20																					
37	SPD	-				3		30	10	10	10	3/4					38	SPARE				1	20																					
39																	40	SPARE				1	20																					
41																	42	SPARE				1	20																					
EQUIPMENT SERVED		CONN. LOAD					1	LF	DF	DEMAND					REMARKS:																													
EQUIPMENT & SUBPANELS		KVA					1	1		KVA					PROVIDE PANELBOARD DIRECTORY																													
		TOTAL CONNECTED						KVA																																				
		MAXIMUM AMPS						XX																																				

PANEL: ETS-UPS-H1															RATING: 150 AMP MLO SERVICE: 480/277V, 3ø, 4W															LUG LOCATION: TOP MOUNTING: SURFACE															A.I.C.: 25,000 TYPE: PANELBOARD																																																																																																																																																																																																																	
CKT. NO.	EQUIPMENT SERVED	KVA	CKT. BKR. POLE/TRIP			BRANCH CIRCUIT			#	Ø	N	GND	C	C	CKT. NO.	EQUIPMENT SERVED	KVA	CKT. BKR. POLE/TRIP			BRANCH CIRCUIT			#	Ø	N	GND	C	C																																																																																																																																																																																																																																	
			A	B	C	A	B	C										A	B	C	A	B	C																																																																																																																																																																																																																																							
1	SPARE		1		20										2	SPARE		1		20																																																																																																																																																																																																																																										
3	SPARE		1		20										4	SPARE		1		20																																																																																																																																																																																																																																										
5	SPARE		1		20										6	SPARE		1		20																																																																																																																																																																																																																																										
7	ETS-UPS-TX1		3		100	(SEE DIAG)									8	SPARE		1		20																																																																																																																																																																																																																																										
9															10	SPARE		1		20																																																																																																																																																																																																																																										
11															12	SPARE		1		20																																																																																																																																																																																																																																										
13	ETS-UPS-TX2	= 3	45	(SEE DIAG)											14	SPARE		1		20																																																																																																																																																																																																																																										
15															16	SPARE		1		20																																																																																																																																																																																																																																										
17															18	SPARE		1		20																																																																																																																																																																																																																																										
19	SPARE		1		20										20	SPARE		1		20																																																																																																																																																																																																																																										
21	SPARE		1		20										22	SPARE		1		20																																																																																																																																																																																																																																										
23	SPARE		1		20										24	SPARE		1		20																																																																																																																																																																																																																																										
25	SPARE		1		20										26	SPARE		1		20																																																																																																																																																																																																																																										
27	SPARE		1		20										28	SPARE		1		20																																																																																																																																																																																																																																										
29	SPARE		1		20										30	SPARE		1		20																																																																																																																																																																																																																																										
31	SPARE		1		20										32	SPARE		1		20																																																																																																																																																																																																																																										
33	SPARE		1		20										34	SPARE		1		20																																																																																																																																																																																																																																										
35	SPARE		1		20										36	SPARE		1		20																																																																																																																																																																																																																																										
37	SPD	= 3	30		30	10	10	10	3/4						38	SPARE		1		20																																																																																																																																																																																																																																										
39															40	SPARE		1		20																																																																																																																																																																																																																																										
41															42	SPARE		1		20																																																																																																																																																																																																																																										
EQUIPMENT SERVED															CONN. LOAD															L.F.															D.F.															DEMAND															REMARKS:																																																																																																																																																																																			
EQUIPMENT & SUBPANELS															KVA															1															1															KVA															PROVIDE PANELBOARD DIRECTORY																																																																																																																																																																																			
																																																																																																																																																																																				</																																																																										



PILO ENGINEERING
540 HIBISCUS BLVD
MERRITT ISLAND, FL 32952
(321) 427-3644
MP-PILOENG@CFL.RR.COM
WWW.PILOENGINEERING.COM
FL C.A. # 26294

MICHAEL PILO, PE
 EL P.E. # 50067

CONSULTANTS:

REVISIONS		
O.	DATE	DESCRIPTION
1		
2		
3		
4		
5		
6		
7		
8		
9		

PROJECT

RELATIVITY SPACE

ELECTRICAL DESIGN VARIOUS FACILITIES

LOCATION

STENNIS SPACE CENTER
MS 39529

OB # RS - 22.02

DRAWN:	MP
--------	----

APPROVED:	MP
-----------	----

DATE:	4.28.2022
-------	-----------

DRAWING TITLE

ELECTRICAL SITE PLAN AEON R ENGINE TEST AREA


DRAWING

E-205

MICHAEL PILO
FL P.E. # 50067


SIGNATURE

ATE

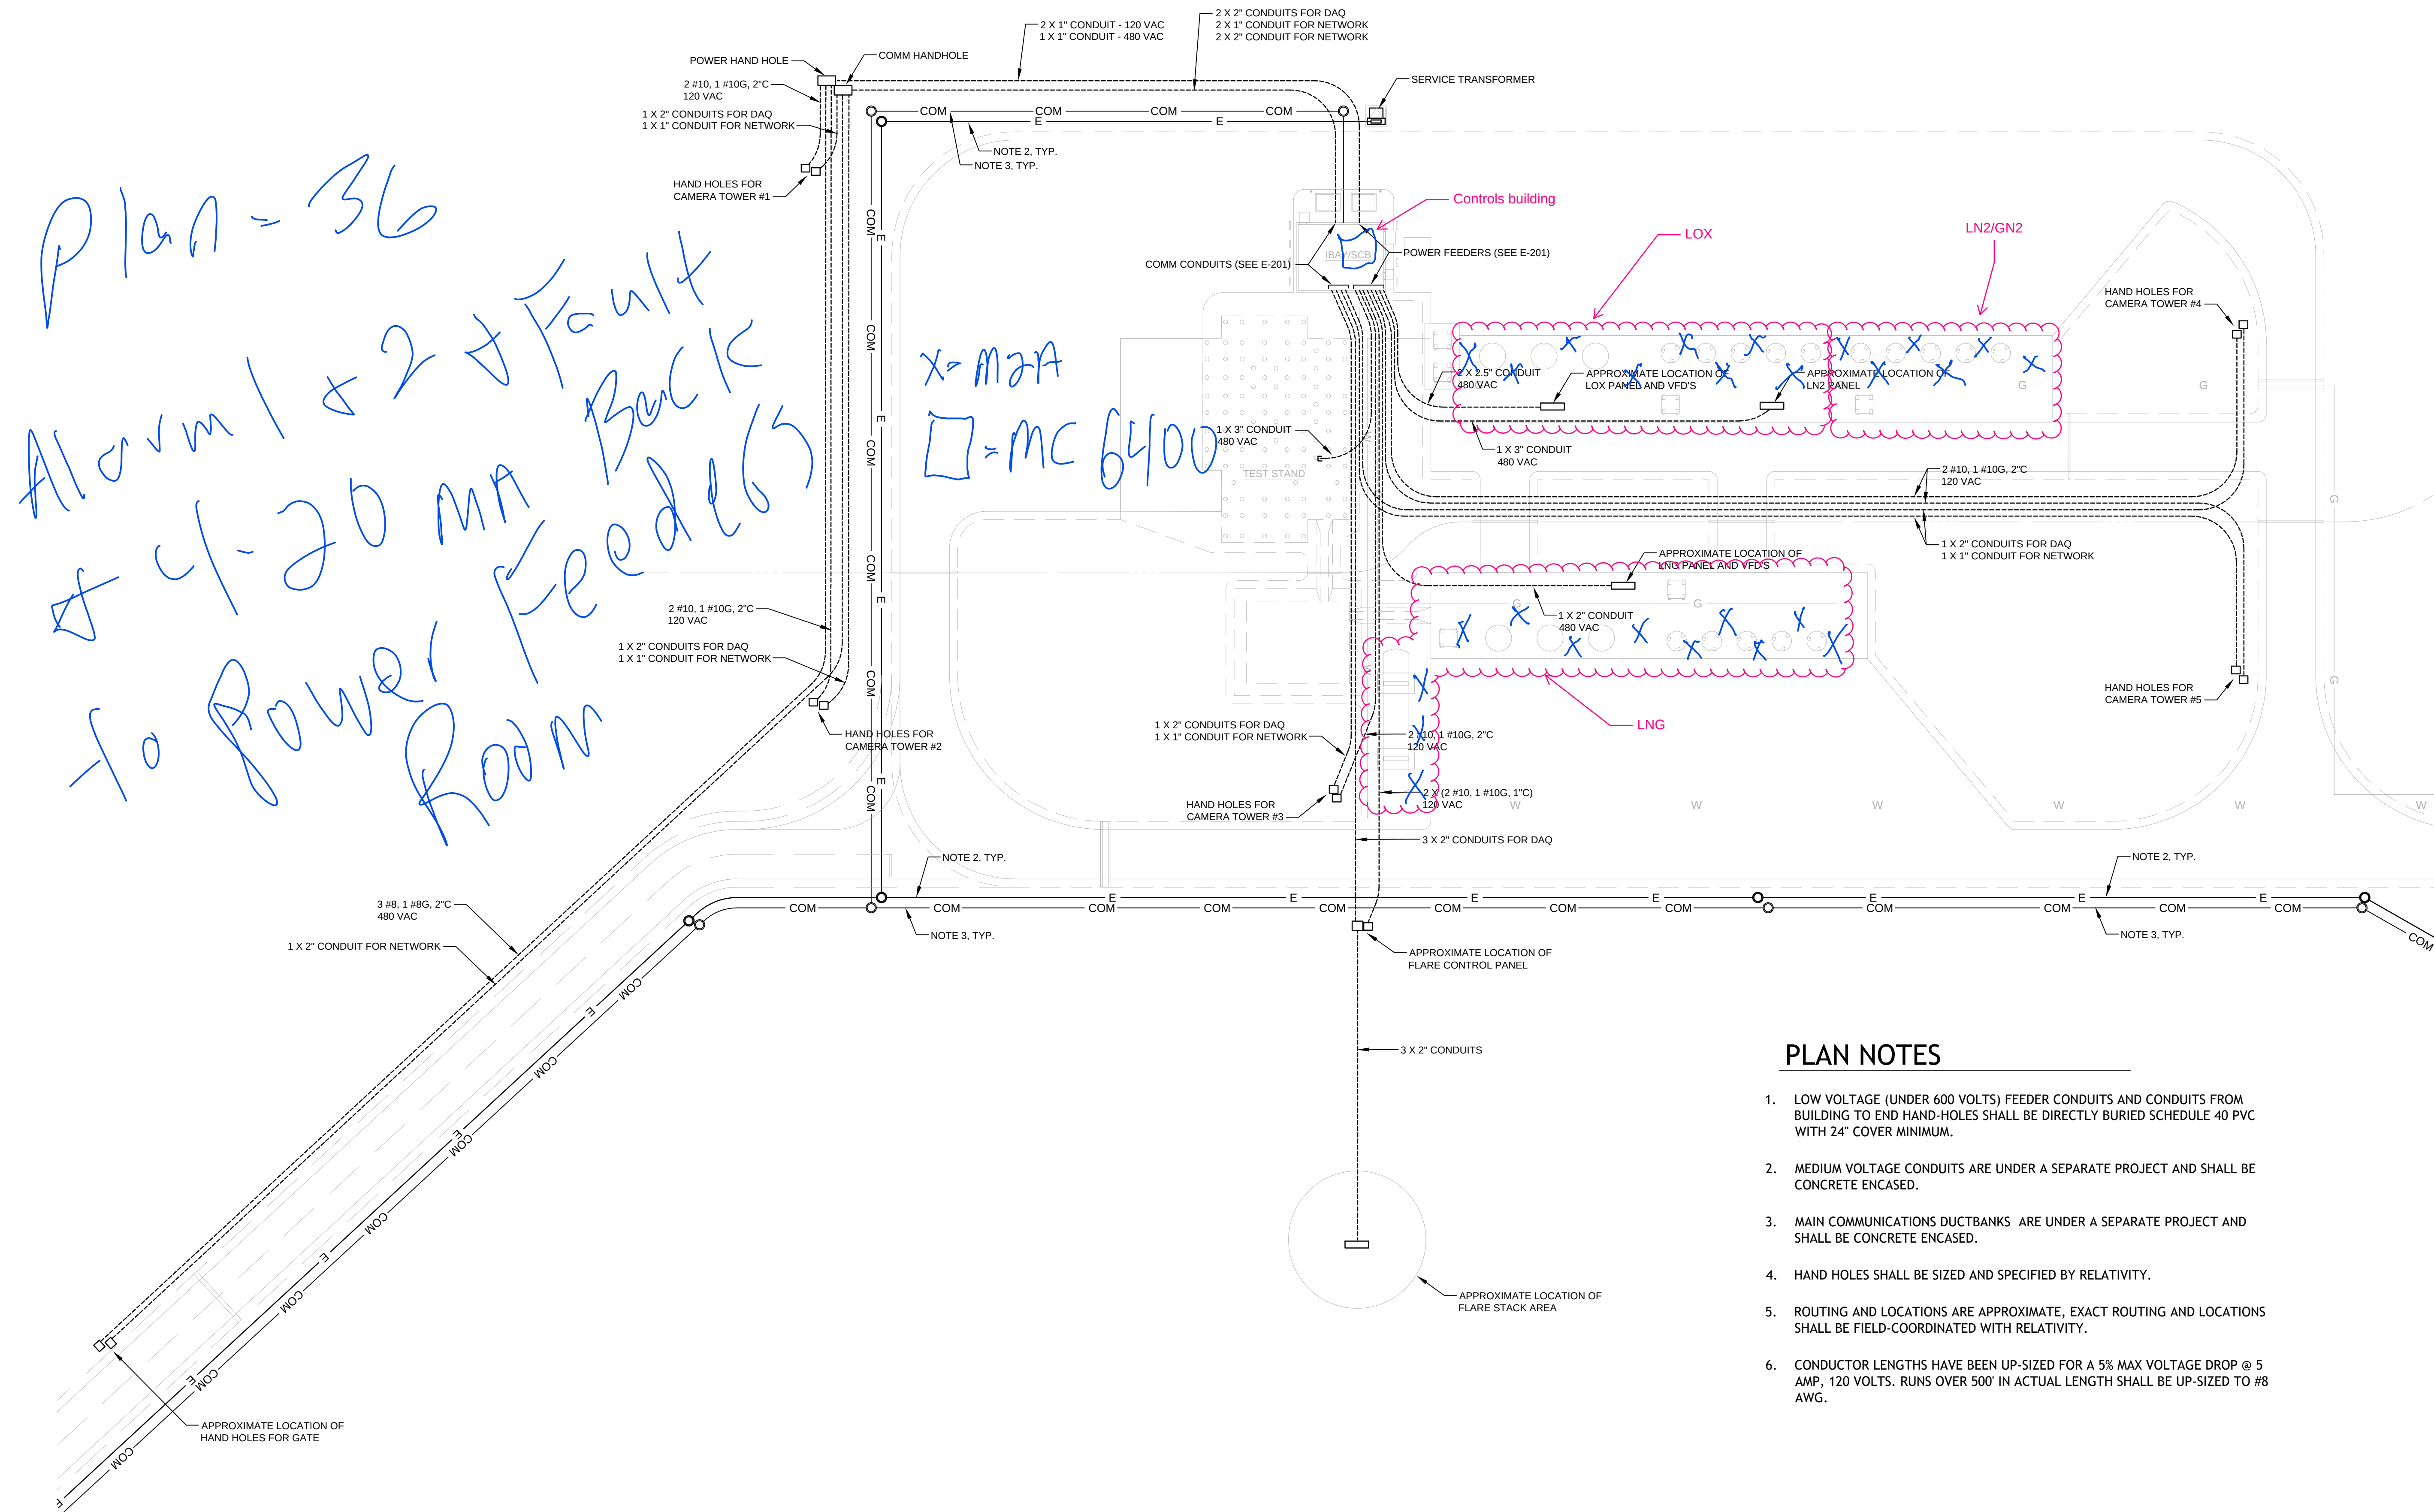

ELECTRICAL SITE PLAN - AEON R ENGINE TEST AREA

SCALE: 1" = 30'

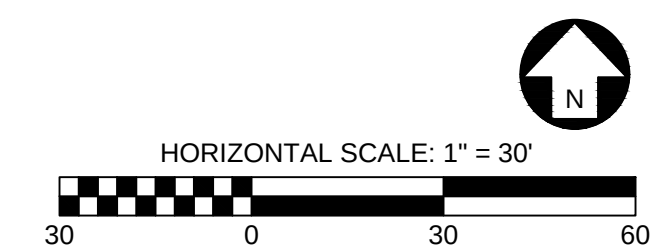

PE

PILO ENGINEERING

540 HIBISCUS AVE'ND
MERRITT ISLAND, FL 32952
(321) 427-3644

360-PILOENG@CFL-RR.COM
WWW.PILOENGINEERING.COM
FL C.A. # 26294

MICHAEL PILO, PE
FL P.E. # 50067

CONSULTANTS:

REVISIONS		
NO.	DATE	DESCRIPTION
1		
2		
3		
4		
5		
6		
7		
8		
9		

LOCATION
STENNIS SPACE CENTER
MS 39529

JOB # RS - 22.02	
DRAWN:	MP
APPROVED:	MP
DATE:	4.28.2022

DRAWING

E-300

MICHAEL PILO FL P.E. # 50067
SIGNATURE
DATE




PILO ENGINEERING
540 H/BISCUS BLVD
MERRITT ISLAND, FL 32952
(321) 427-3644
JAP-PILOENGIN@CFL.RR.COM
WWW.PILOENGINERING.COM
F.L.C.A. # 26294

MICHAEL PILO, PE
F.L.P.E. # 50067

CONSULTANTS:

REVISIONS		
NO.	DATE	DESCRIPTION
1		
2		
3		
4		
5		
6		
7		
8		
9		

PROJECT

ELECTRICAL DESIGN
VARIOUS FACILITIES

LOCATION

STENNIS SPACE CENTER
MS 39529

JOB # RS - 22.02

DRAWN:	MP
--------	----

APPROVED:	MP
-----------	----

DATE:	4.28.2022
-------	-----------

DRAWING TITLE

POWER/I.T. BUILDING
ELECTRICAL PLAN
WATER PAD AREA


DRAWING

E-301

MICHAEL PILO
FL P.E. # 50067

SIGNATURE

DATE _____

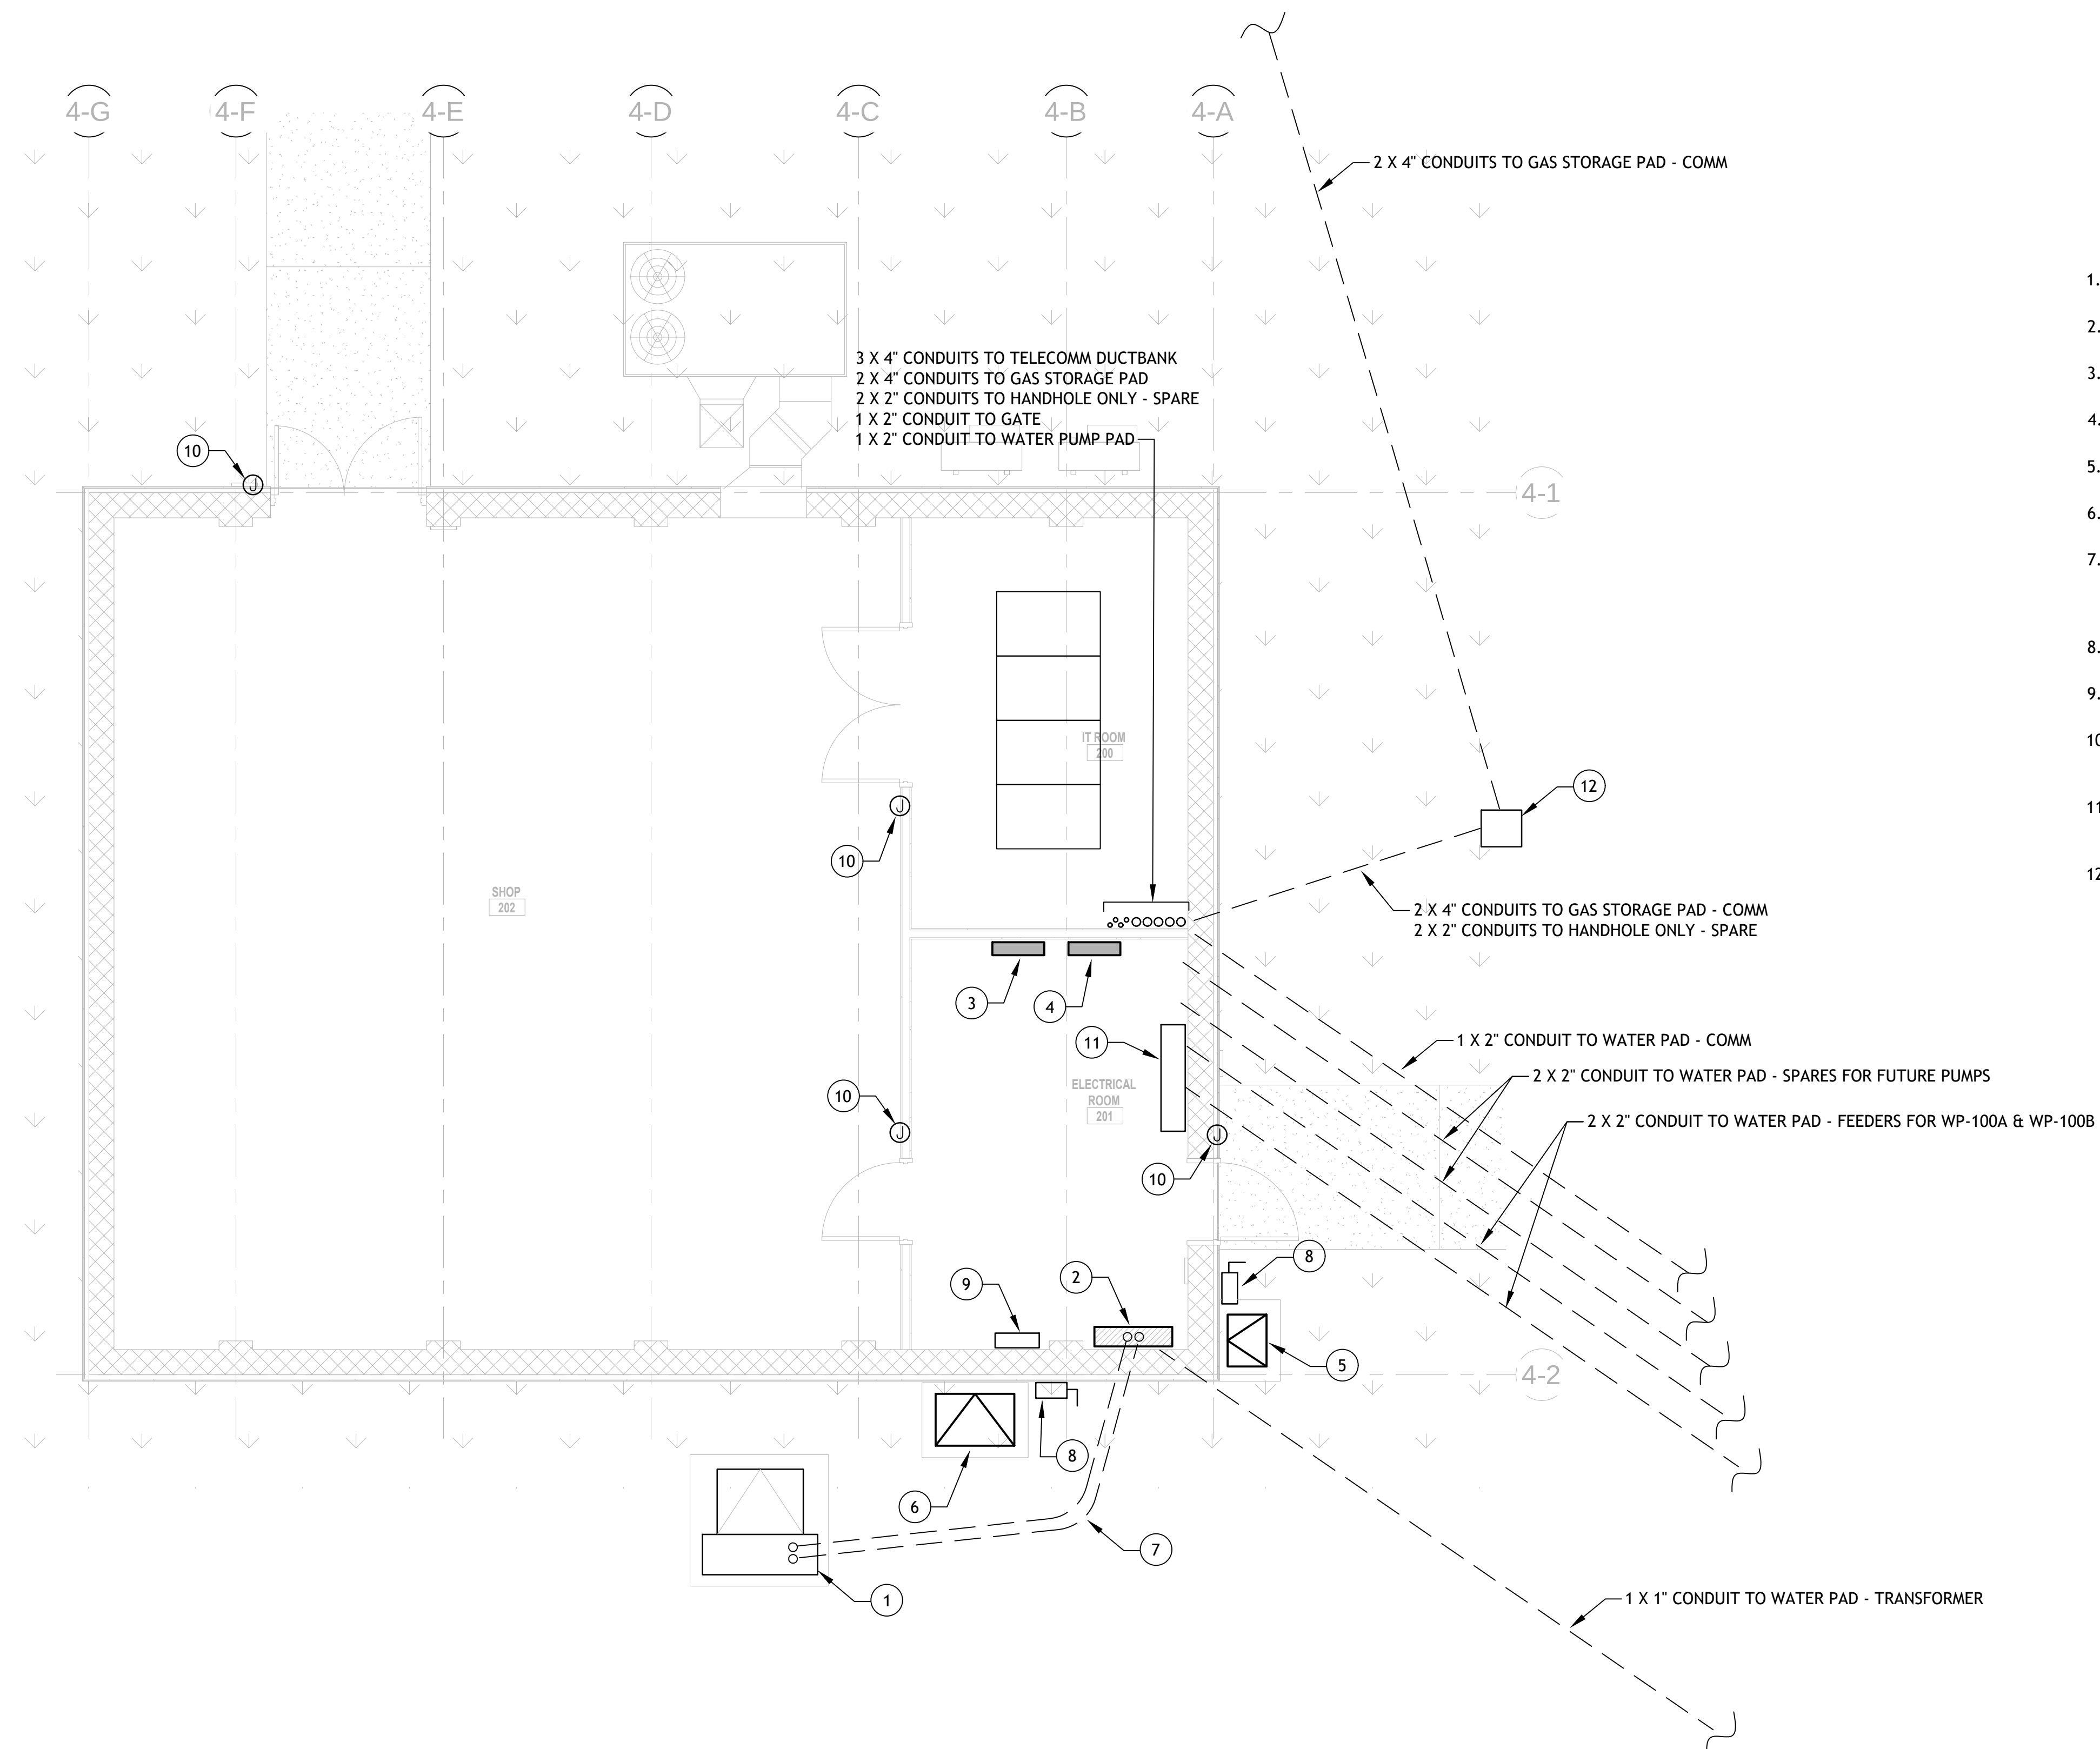

POWER/I.T. BUILDING ELECTRICAL PLAN - WATER PAD AREA

SCALE: 1/4" = 1'-0"

CONSULTANTS:

REVISIONS

NO.	DATE	DESCRIPTION
1		
2		
3		
4		
5		
6		
7		
8		
9		

PROJECT

RELATIVITY SPACE
ELECTRICAL DESIGN
VARIOUS FACILITIES

LOCATION

STENNIS SPACE CENTER
MS 39529

JOB # RS - 22.02

DRAWN: MP

APPROVED: MP

DATE: 4.28.2022

DRAWING TITLE

**POWER/I.T. BUILDING
ELECTR/LIGHTING PLAN
WATER PAD AREA**

DRAWING

E-302

MICHAEL PILO
FL P.E. # 50067

SIGNATURE

DATE

LIGHTING NOTES

- EXIT AND EMERGENCY LIGHTS SHALL BE CONNECTED TO THE UNSWITCHED SIDE OF LIGHT CIRCUIT.
- INTERIOR LIGHTING SHALL BE CONTROLLED THROUGH ARP LIGHTING CONTROL PANEL WITH LOW VOLTAGE WALL SWITCHES AND VACANCY SENSORS (WHERE SHOWN). EXTERIOR LIGHTING SHALL BE CONTROLLED WITH ARP LIGHTING CONTROL PANEL AND ONE LOW VOLTAGE WALL SWITCH LOCATED IN ELECTRICAL ROOM.
- ALL LIGHTING FIXTURES SHALL BE SERVED BY PANEL AND CIRCUIT NUMBER INDICATED.
- HALF-SHADED FIXTURES SHALL CONTAIN EMERGENCY LIGHT BATTERY BACKUP.


LIGHTING FIXTURE SCHEDULE

#	TYPE	MANUFACTURER / PART #	LAMP	LUMENS	W
C1	LINEAR SUSPENDED LED, 4', WITH STEM	LITHONIA / BLWP4-60L-ADSM-LP840	LED	6,000	60
W1	WALL MOUNTED EXTERIOR, CUTOFF	LITHONIA / DSKW1-LED-20C-350-50K-T3S	LED	3,000	34
EX	EXIT LIGHT WITH BATTERY BACKUP	LITHONIA	LED	-	5


FIXTURE SELECTION REPRESENT BASIS OF DESIGN, EQUAL SUBSTITUTES ARE ACCEPTABLE.

ELECTRICAL NOTES

- ALL EQUIPMENT AND DEVICES SHALL BE FED FROM PANELS AND CIRCUITS INDICATED, SEE E-201 FOR PANEL LOCATION. SEE PANEL SCHEDULES, E-204
- PROVIDE DISCONNECTS, STARTERS, FEEDERS, AND CONNECTIONS FOR NEW DEVICES, AND HVAC EQUIPMENT AS SHOWN. ALL EQUIPMENT LOCATED OUTSIDE SHALL BE WEATHERPROOF, WIRING METHODS SHALL BE SUITABLE FOR WET LOCATIONS.

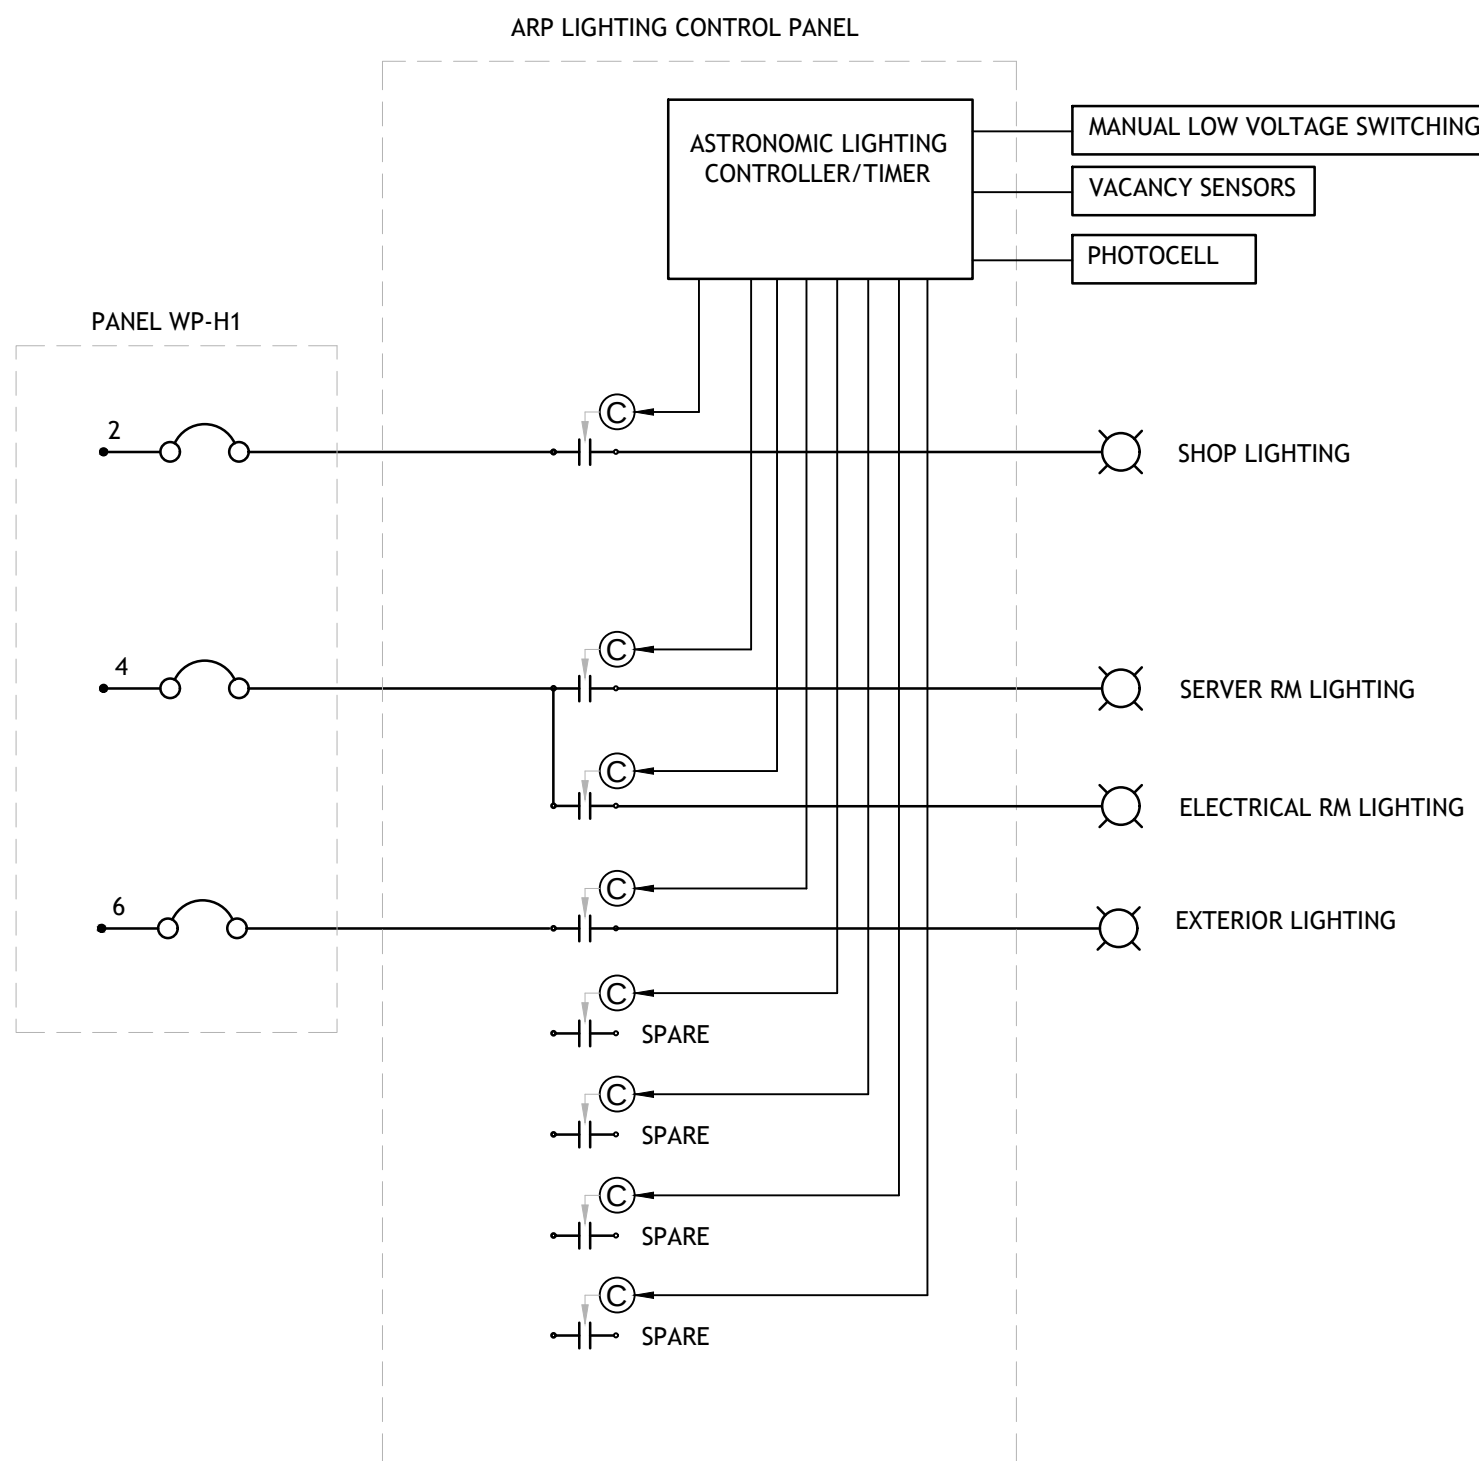

LIGHT CONTROL DIAGRAM

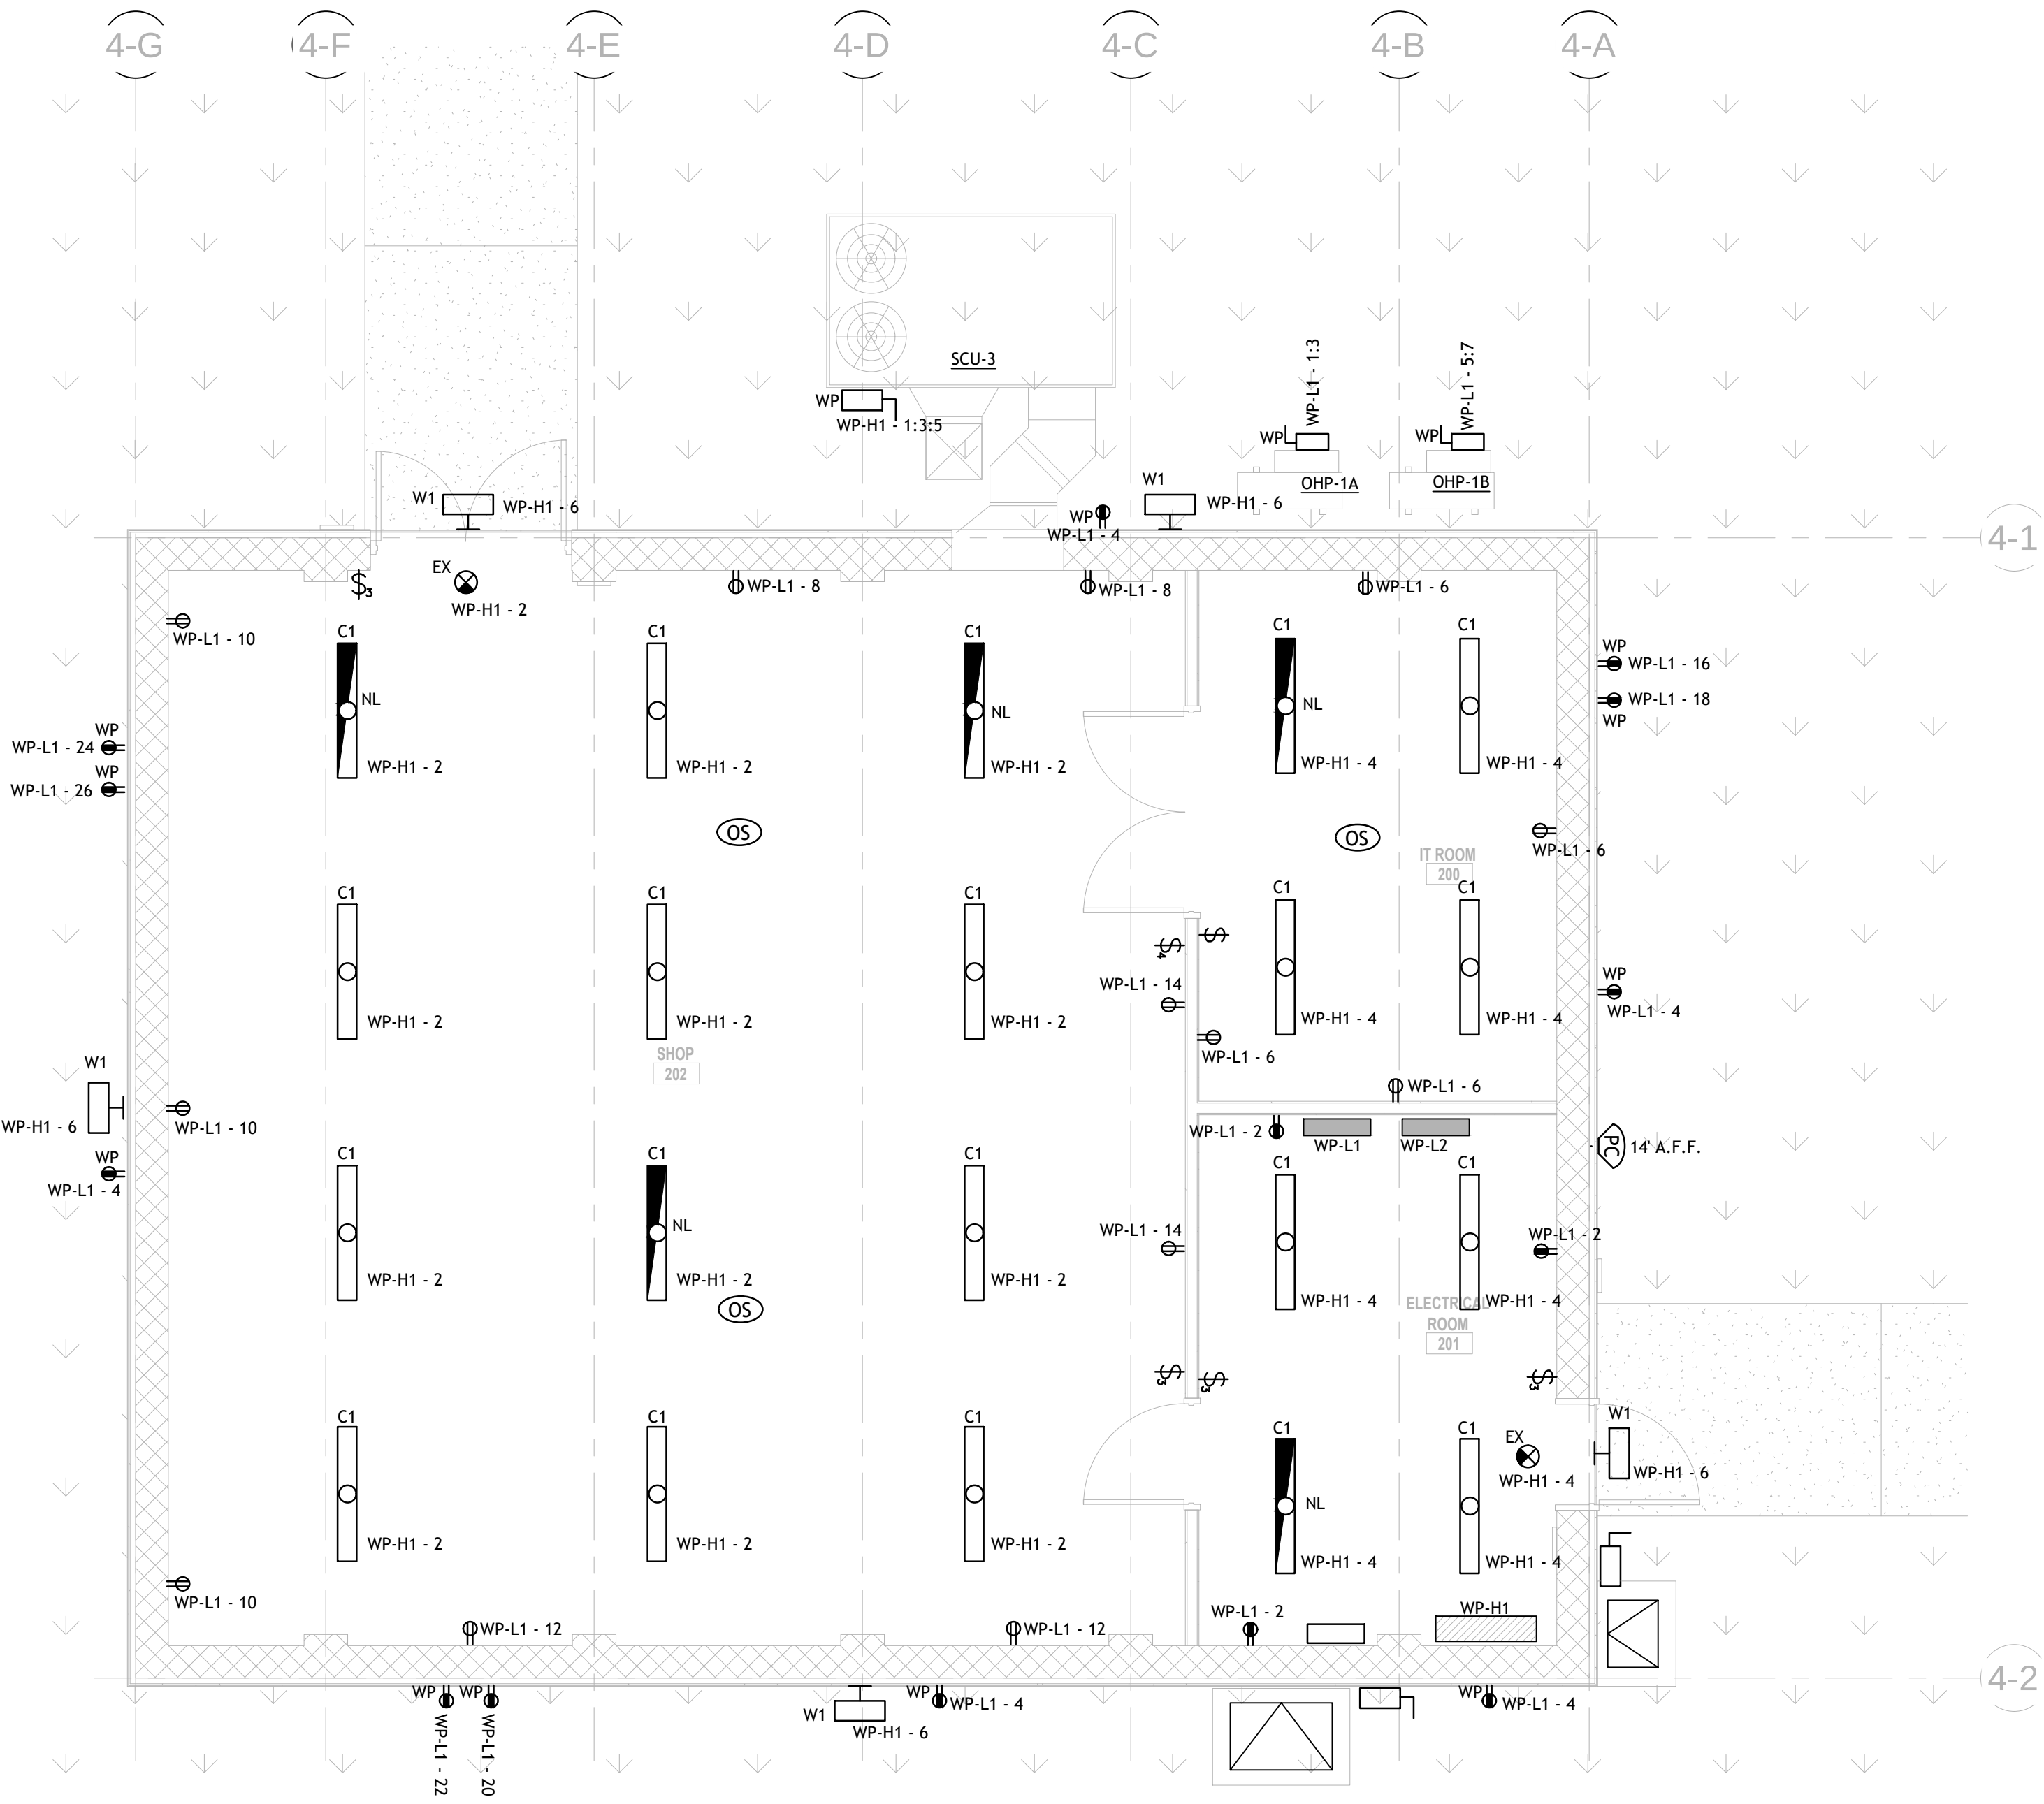

IBAY/SCB BUILDING ELECTRICAL AND LIGHITNG PLAN - WATER PAD AREA

SCALE: 1/4" = 1'-0"

CONSULTANTS:


REVISIONS		
NO.	DATE	DESCRIPTION
1		
2		
3		
4		
5		
6		
7		
8		
9		

PROJECT	
RELATIVITY SPACE	
ELECTRICAL DESIGN VARIOUS FACILITIES	
LOCATION	
STENNIS SPACE CENTER MS 39529	
JOB #	RS - 22.02
DRAWN:	MP
APPROVED:	MP
DATE:	4.28.2022

DRAWING TITLE
POWER/I.T. BUILDING GROUNDING PLAN WATER PAD AREA


DRAWING
E-303

MICHAEL PILO FL P.E. # 50067
SIGNATURE
DATE

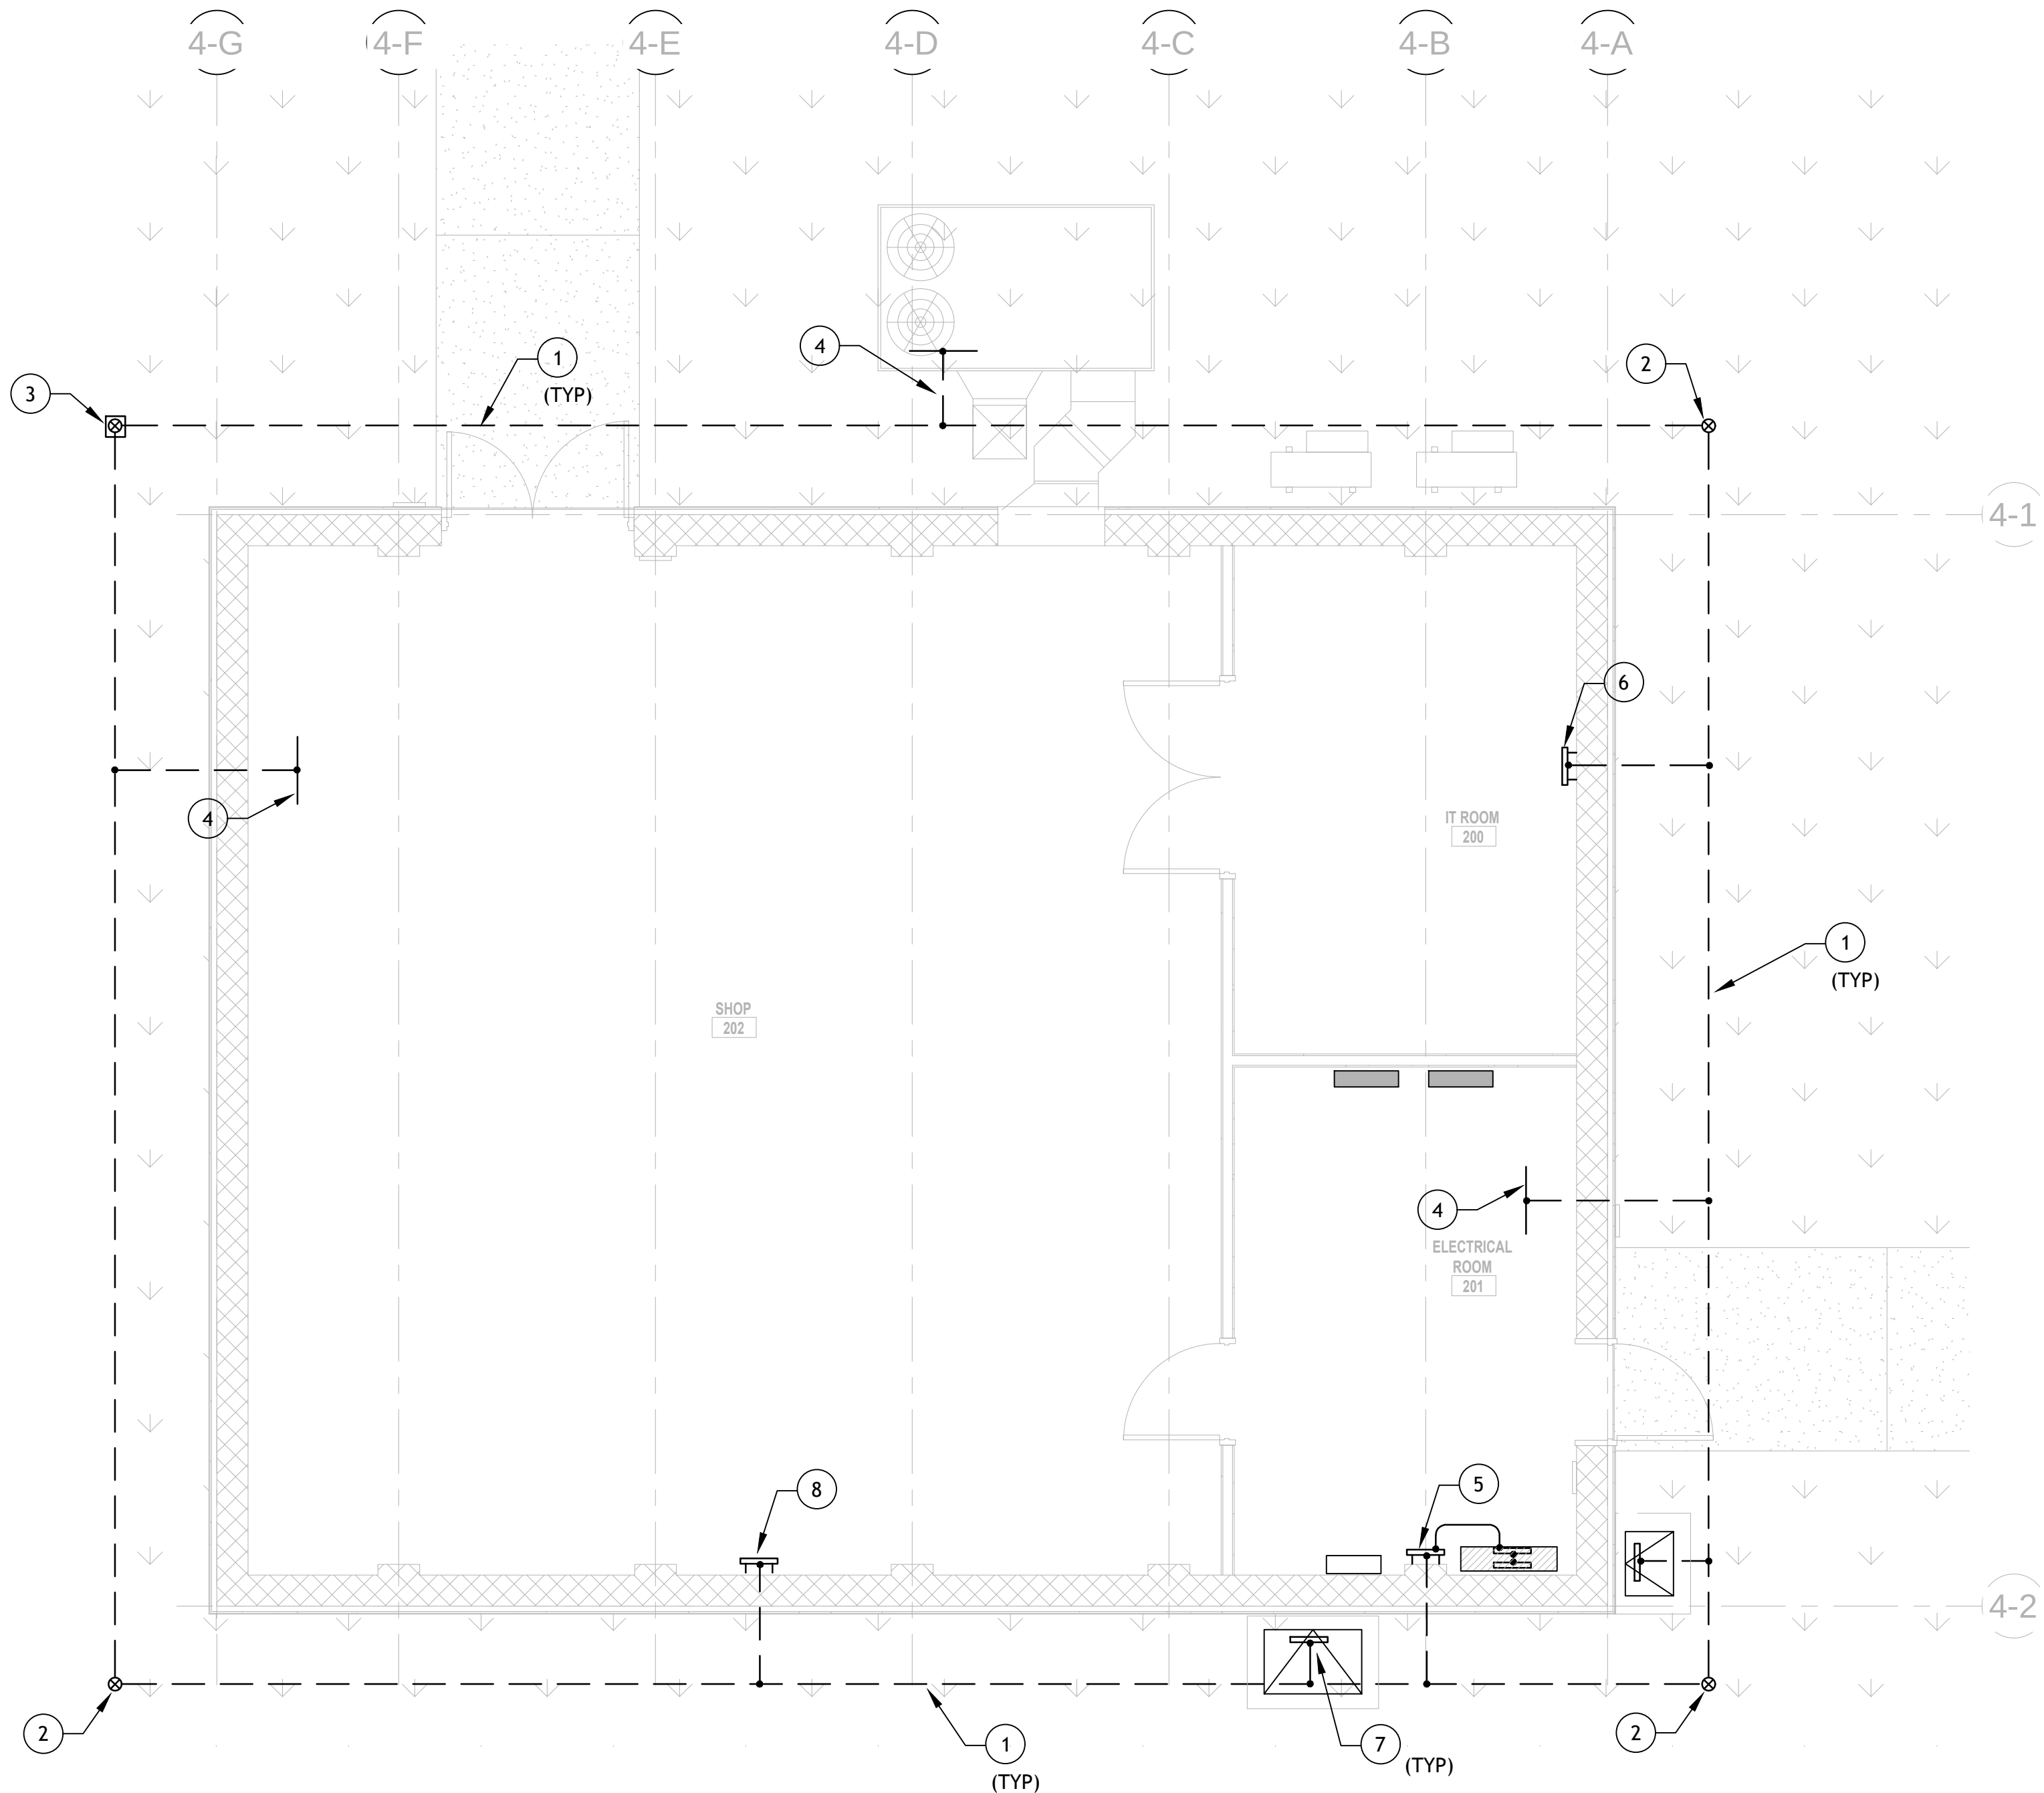


IBAY/SCB BUILDING GROUNDING PLAN - WATER PAD AREA

SCALE: 1/4" = 1'-0"

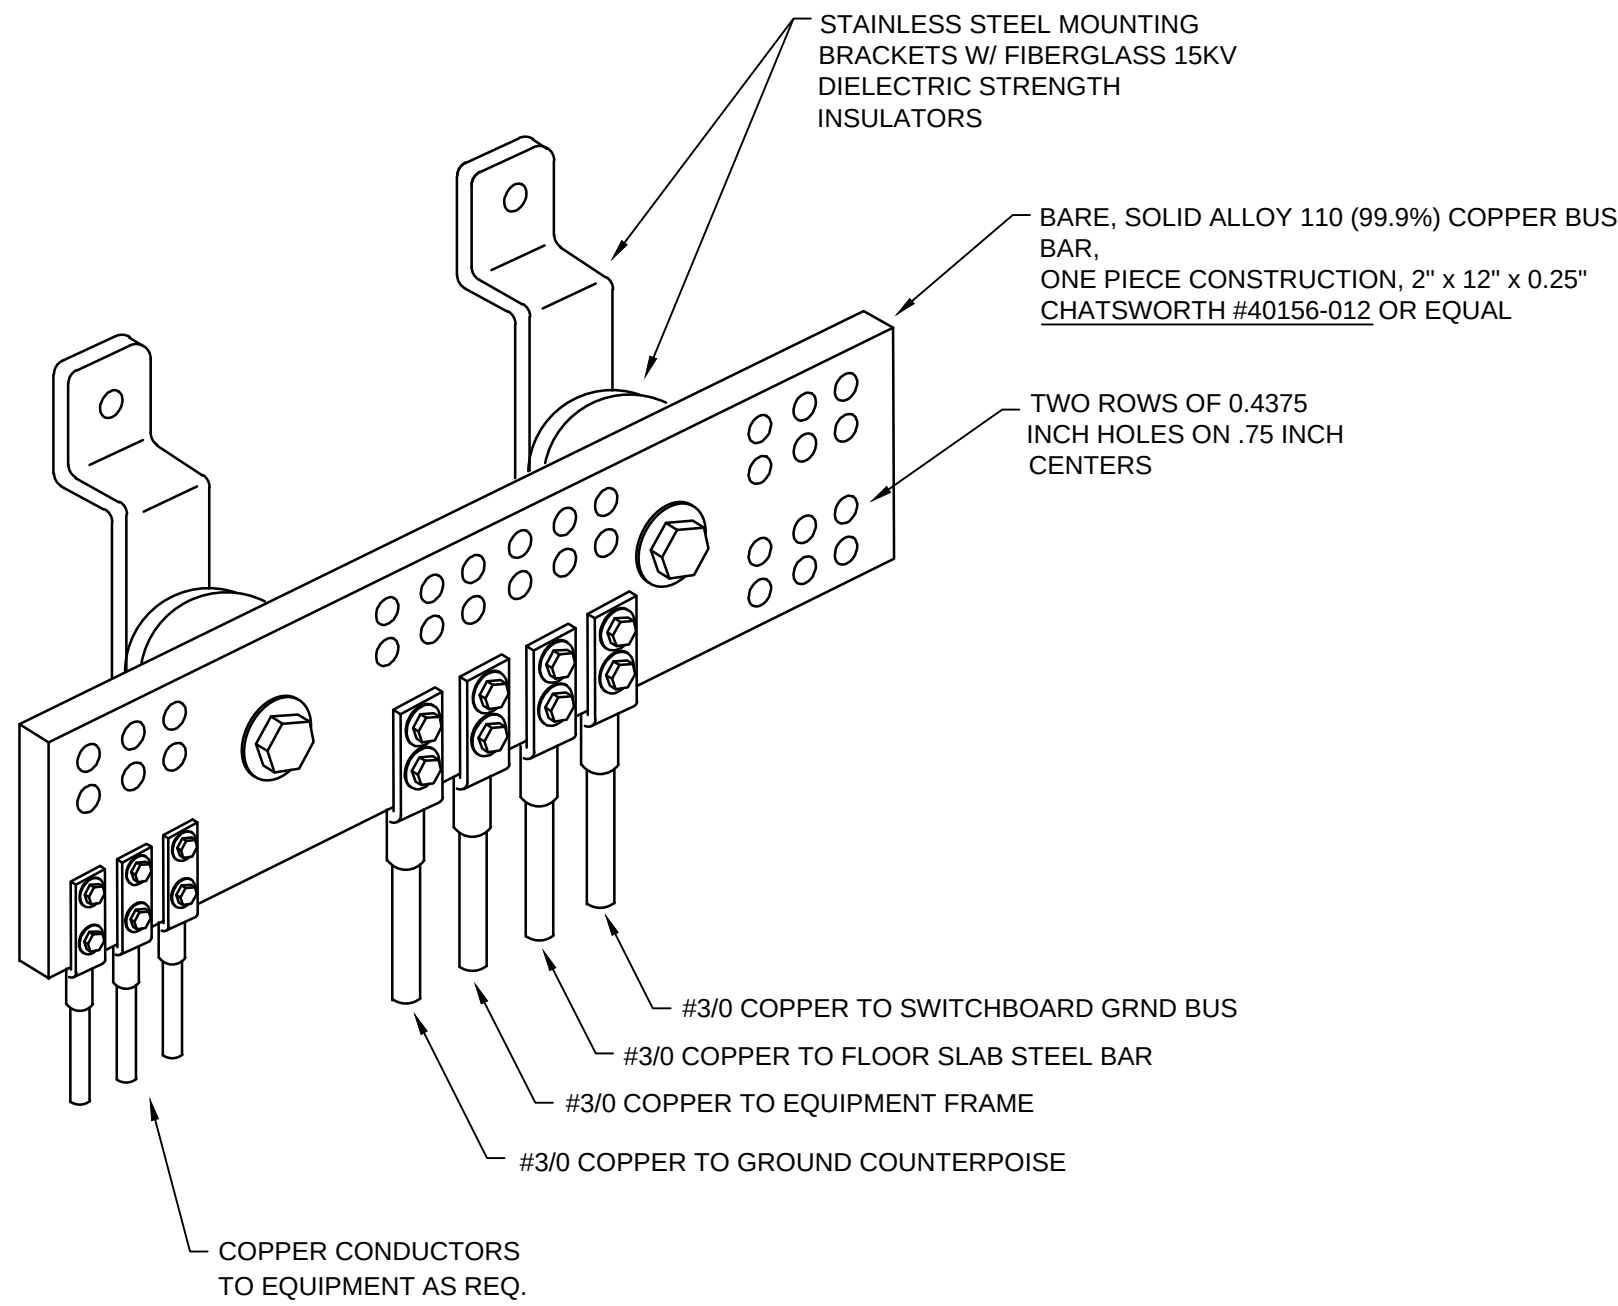

GROUND BUS BAR DETAIL
SCALE: NTS

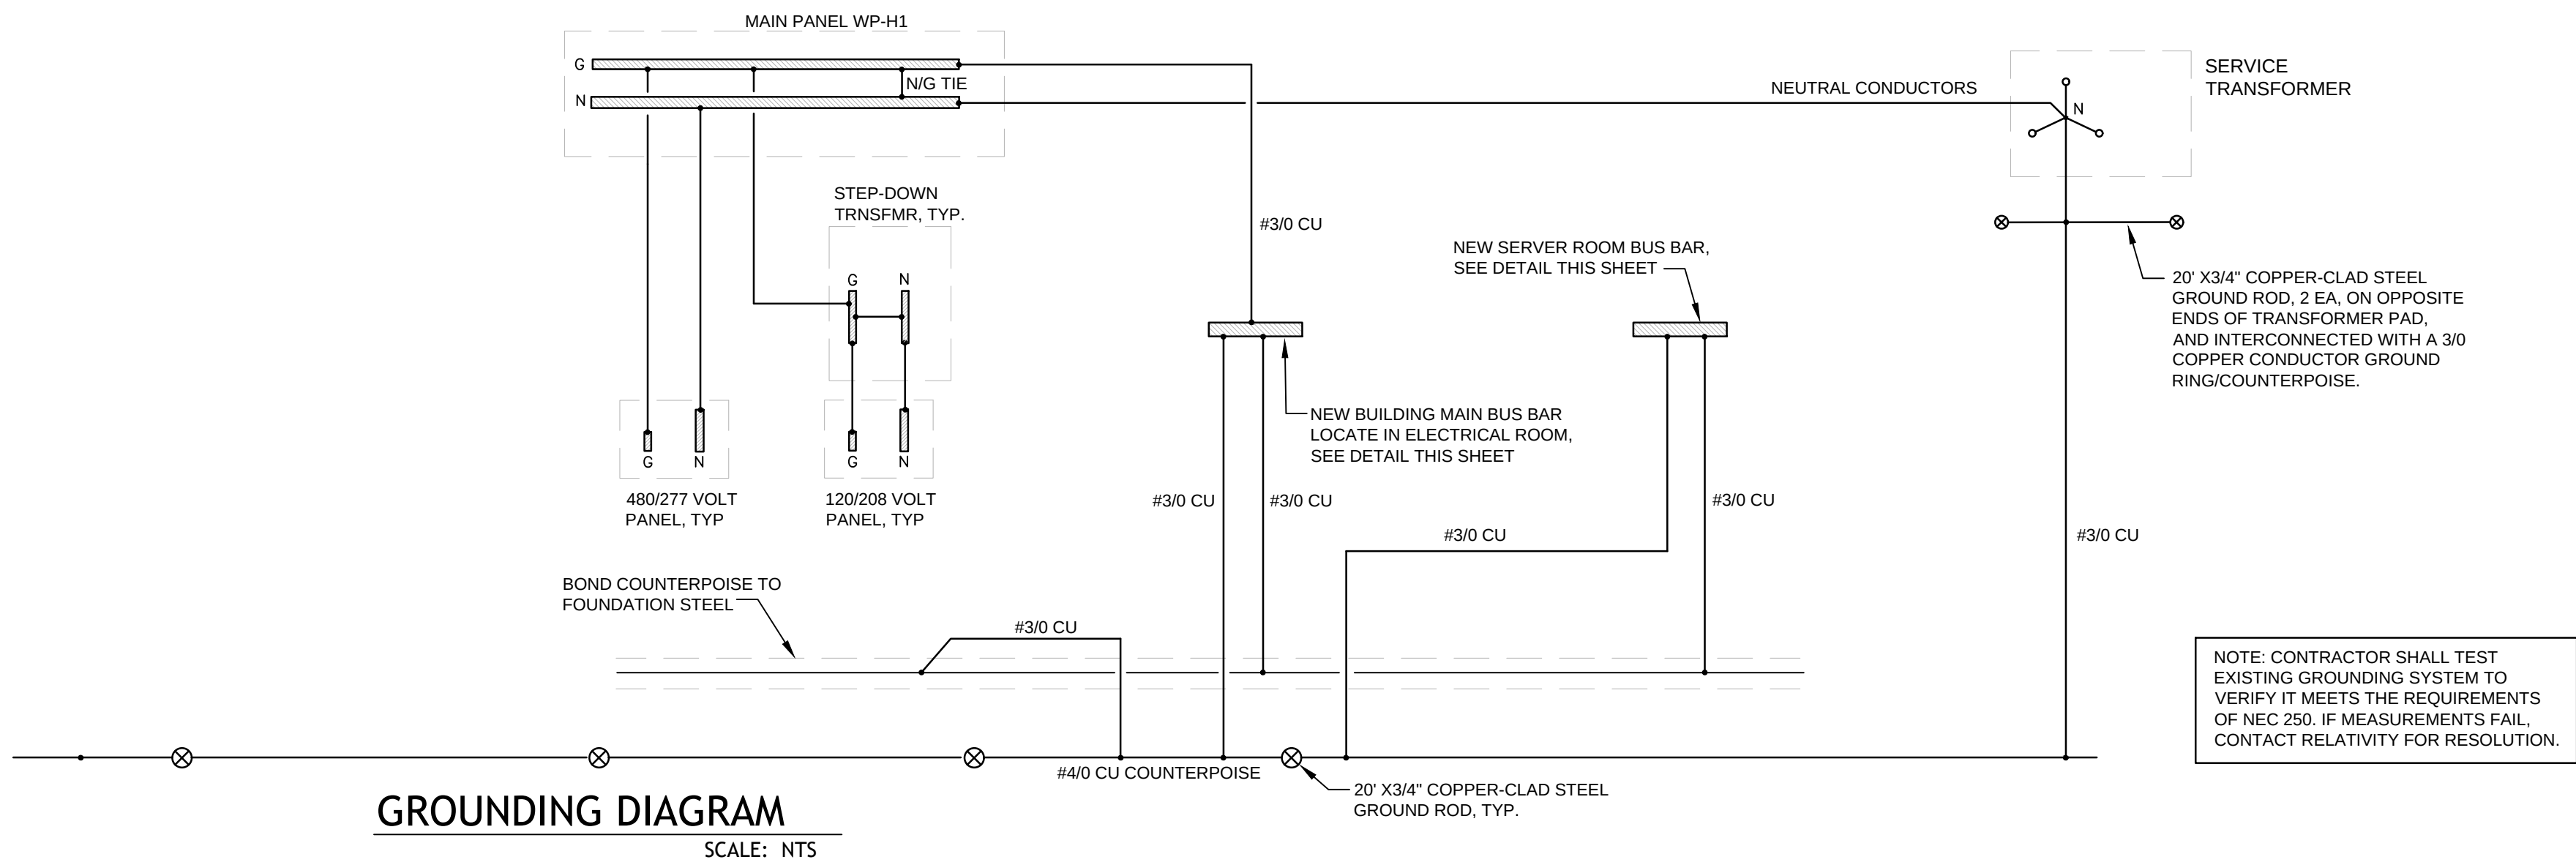

GROUNDING DIAGRAM
SCALE: NTS

PLAN NOTES

#

1. PROVIDE AND INSTALL GROUND RING (COUNTERPOISE), TO CONSIST OF A SINGLE STRANDED #4/0 BARE COPPER CONDUCTOR, DIRECTLY BURIED 30" BELOW GRADE AND APPROXIMATELY 4' FROM EDGE OF FOUNDATION, AND PROVIDE GROUND RODS AS INDICATED. ALL CONNECTIONS TO COUNTERPOISE AND ALL JOINTS SHALL BE EXOTHERMICALLY WELDED, WITH THE EXCEPTION OF CONNECTION TO GROUND TEST WELL, WHICH SHALL BE MADE WITH MECHANICAL CONNECTORS.
2. GROUND ROD, 20' X 3/4"D, DRIVEN TO 12" BELOW GRADE. ALL CONNECTIONS TO GROUND ROD SHALL BE EXOTHERMICALLY WELDED.
3. GROUND WELL WITH GROUND ROD, 20' X 3/4"D, AND SLEEVE W/ COVER. ALL CONNECTIONS TO GROUND ROD SHALL BE UL-LISTED MECHANICAL CLAMPS.
4. PROVIDE CABLE BOND FROM CONCRETE FOUNDATION STEEL TO GROUND RING. CONDUCTOR SHALL BE #3/0 BARE STRANDED COPPER.
5. INSTALL GROUND BUS COPPER BAR IN ELECTRICAL ROOM, 18" A.F.F. PROVIDE BOND TO COUNTERPOISE AND TO BUILDING FOUNDATION STEEL AS INDICATED. CABLE CONNECTIONS TO BAR SHALL BE BOLT-ON MECHANICAL CRIMP CONNECTORS.
6. INSTALL GROUND BUS COPPER BAR IN SERVER ROOM, 18" A.F.F. PROVIDE BOND TO COUNTERPOISE AND TO BUILDING FOUNDATION STEEL AS INDICATED. CABLE CONNECTIONS TO BAR SHALL BE BOLT-ON MECHANICAL CRIMP CONNECTORS.
7. PROVIDE CONNECTIONS TO EQUIPMENT AS INDICATED.
8. INSTALL GROUND BUS COPPER BAR IN MAINTENANCE ROOM, 18" A.F.F. PROVIDE BOND TO COUNTERPOISE AND TO BUILDING FOUNDATION STEEL AS INDICATED. CABLE CONNECTIONS TO BAR SHALL BE BOLT-ON MECHANICAL CRIMP CONNECTORS

Relativity



MICHAEL PILO, PE
FL P.E. # 50067

CONSULTANTS:

REVISIONS		
NO.	DATE	DESCRIPTION
1		
2		
3		
4		
5		
6		
7		
8		
9		

PROJECT

RELATIVITY SPACE

ELECTRICAL DESIGN
VARIOUS FACILITIES

LOCATION

STENNIS SPACE CENTER
MS 39529

JOB # RS - 22.02

DRAWN: MF

APPROVED:	MF
-----------	----

DATE:	4.28.2022
-------	-----------

DRAWING TITLE

PANEL SCHEDULES
WATER PAD AREA

DRAWING

E-304

MICHAEL PILO
FL P.E. # 50067

SIGNATURE

DATE _____

PANEL:

WP-MSB

RATING: 600 AMP MCB (SERV-RTD)

SERVICE: 480/277V, 3ø, 4W

LUG LOCATION: BOTTOM SURFACE

MOUNTING: SURFACE

A.I.C.: 65,000

PANELBOARD TYPE:

CKT. NO.	EQUIPMENT SERVED	KVA	CKT.BKR. POLE TRIP	BRANCH #	CIRCUIT N	GND C	Ø	CKT. NO.	EQUIPMENT SERVED	KVA	CKT.BKR. POLE TRIP	BRANCH #	CIRCUIT N	GND C	
1	SCU-3		3	70	(SEE DIAG)			2	LIGHTING		1	20	10	10	3/4"
3								4	LIGHTING		1	20	10	10	3/4"
5								6	LIGHTING		1	20	10	10	3/4"
7	WP-TX2	3	100	(SEE DIAG)				8	SPARE		1	20			
9								10	SPARE		1	20			
11								12	SPARE		1	20			
13	WP-TX1	-	3	45	(SEE DIAG)			14	SPARE		1	20			
15								16	SPARE		1	20			
17								18	SPARE		1	20			
19	FUTURE WP--H1	3	400	(SEE DIAG)				20	SPARE		1	20			
21								22	SPARE		1	20			
23								24	SPARE		1	20			
25	FUTURE WP--100A	3	125	(SEE DIAG)				26	SPARE		1	20			
27								28	SPARE		1	20			
31								30	SPARE		1	20			
33	FUTURE WP--100B	3	125	(SEE DIAG)				32	SPARE		1	20			
35								34	SPARE		1	20			
37	SPD	-	3	30	10	10	3/4"	36	SPARE		1	20			
39								38	SPARE		1	20			
41								40	SPARE		1	20			
								42	SPARE		1	20			

EQUIPMENT SERVED

EQUIPMENT & SUBPANELS

CONN. LOAD

KVA

L.F.

1

D.F.

1

DEMAND

KVA

REMARKS:

PROVIDE PANELBOARD TYPE:

TOTAL CONNECTED MAXIMUM AMPS

KVA

XX

PANEL:			RATING: 100 AMP MCB SERVICE: 120/208V, 3ø, 4W					LUG LOCATION: TOP SURFACE					A.I.C.: 10,000				
WP-L1								MOUNTING:					TYPE: PANELBOARD				
CKT. NO.	EQUIPMENT SERVED	KVA	CKT.BKR. POLE TRIP	BRANCH ø	N	CIRCUIT GND	C	CKT. NO.	EQUIPMENT SERVED	KVA	CKT.BKR. POLE TRIP	BRANCH ø	N	CIRCUIT GND	C		
3	0HP-1A	2	30	1	10	-	10 3/4	2	RECEPTABLE INTERIOR	1	1	20	12	12	12 3/4		
3	1	1	1	1	10	-	10 3/4	4	RECEPTABLE EXTERIOR	1	1	20	12	12	12 3/4		
5	0HP-1B	2	20	1	10	-	10 3/4	6	RECEPTABLE INTERIOR	1	1	20	12	12	12 3/4		
7	1	1	1	1	10	-	10 3/4	8	RECEPTABLE INTERIOR	1	1	20	12	12	12 3/4		
9	1	1	20	1	10	-	10 3/4	10	RECEPTABLE INTERIOR	1	1	20	12	12	12 3/4		
11	SPARE	1	20	1	10	-	10 3/4	12	RECEPTABLE INTERIOR	1	1	20	12	12	12 3/4		
13	SPARE	1	20	1	10	-	10 3/4	14	RECEPTABLE INTERIOR	1	1	20	12	12	12 3/4		
15	SPARE	1	20	1	10	-	10 3/4	16	DEDICATED EXT RECEPT	1	1	20	12	12	12 3/4		
17	SPARE	1	20	1	10	-	10 3/4	18	DEDICATED EXT RECEPT	1	1	20	12	12	12 3/4		
19	SPARE	1	20	1	10	-	10 3/4	20	DEDICATED EXT RECEPT	1	1	20	12	12	12 3/4		
21	SPARE	1	20	1	10	-	10 3/4	22	DEDICATED EXT RECEPT	1	1	20	12	12	12 3/4		
23	SPARE	1	20	1	10	-	10 3/4	24	DEDICATED EXT RECEPT	1	1	20	12	12	12 3/4		
25	SPARE	1	20	1	10	-	10 3/4	26	DEDICATED EXT RECEPT	1	1	20	12	12	12 3/4		
27	SPARE	1	20	1	10	-	10 3/4	28	SPARE	1	20						
29	SPARE	1	20	1	10	-	10 3/4	30	SPARE	1	20						
31	SPARE	1	20	1	10	-	10 3/4	32	SPARE	1	20						
33	SPARE	1	20	1	10	-	10 3/4	34	SPARE	1	20						
35	SPARE	1	20	1	10	-	10 3/4	36	SPARE	1	20						
37	SPARE	1	20	1	10	-	10 3/4	38	SPARE	1	20						
39	SPARE	1	20	1	10	-	10 3/4	40	SPARE	1	20						
41	SPARE	1	20	1	10	-	10 3/4	42	SPARE	1	20						
EQUIPMENT SERVED			CONN. LOAD			L.F.			D.F.			DEMAND			REMARKS:		
EQUIPMENT			KVA			1			1			KVA			PROVIDE PANELBOARD DIRECTORY		
			TOTAL CONNECTED									KVA					
			MAXIMUM AMPS									XX					

PANEL: _____										RATING: 225 AMP MCB					LUG LOCATION: TOP					A.I.C. 10.000									
WP-L2										SERVICE: 120/208V, 3ø, 4W					MOUNTING: _____					SURFACE: _____					TYPE: PANELBOARD				
CKT. NO.	EQUIPMENT SERVED	KVA	CKT. BKR. POLE	TRIP	BRANCH ø	CIRCUIT N	GND	C	ø	CKT. NO.	EQUIPMENT SERVED	KVA	CKT. BKR. POLE	TRIP	BRANCH ø	CIRCUIT N	GND	C	ø										
1	SPARE	1	20							2	SPARE	1	20																
3	SPARE	1	20							4	SPARE	1	20																
5	SPARE	1	20							6	SPARE	1	20																
7	SPARE	1	20							8	SPARE	1	20																
9	SPARE	1	20							10	SPARE	1	20																
11	SPARE	1	20							12	SPARE	1	20																
13	SPARE	1	20							14	SPARE	1	20																
15	SPARE	1	20							16	SPARE	1	20																
17	SPARE	1	20							18	SPARE	1	20																
19	SPARE	1	20							20	SPARE	1	20																
21	SPARE	1	20							22	SPARE	1	20																
23	SPARE	1	20							24	SPARE	1	20																
25	SPARE	1	20							26	SPARE	1	20																
27	SPARE	1	20							28	SPARE	1	20																
29	SPARE	1	20							30	SPARE	1	20																
31	SPARE	1	20							32	SPARE	1	20																
33	SPARE	1	20							34	SPARE	1	20																
35	SPARE	1	20							36	SPARE	1	20																
37	SPARE	1	20							38	SPARE	1	20																
39	SPARE	1	20							40	SPARE	1	20																
41	SPARE	1	20							42	SPARE	1	20																

EQUIPMENT SERVED		CONN. LOAD		L.F.	D.F.	DEMAND	REMARKS:
EQUIPMENT	KVA	1	1		KVA	PROVIDE PANELBOARD DIRECTORY	
TOTAL CONNECTED						KVA	
MAXIMUM AMPS						xx	



PILO ENGINEERING
540 HIBISCUS BLVD
MERRITT ISLAND, FL 32952
(321) 427-3644
MP-PILOENG@CFL.RR.COM
WWW.PILOENGINEERING.COM
FL C.A. # 26294

MICHAEL PILO, PE
FL P.E. # 50067

CONSULTANTS:

REVISIONS		
O.	DATE	DESCRIPTION
1		
2		
3		
4		
5		
6		
7		
8		
9		

PROJECT

RELATIVITY SPACE

ELECTRICAL DESIGN VARIOUS FACILITIES

ICATION

STENNIS SPACE CENTER
MS 39529

OB # RS - 22.02

DRAWN:	MP
--------	----

APPROVED:	MP
-----------	----

DATE:	4.28.2022
-------	-----------

DRAWING TITLE

ELECTRICAL SITE PLAN WATER PAD AREA


DRAWING

E-305

MICHAEL PILO
FL P.E. # 50067

SIGNATURE

TE

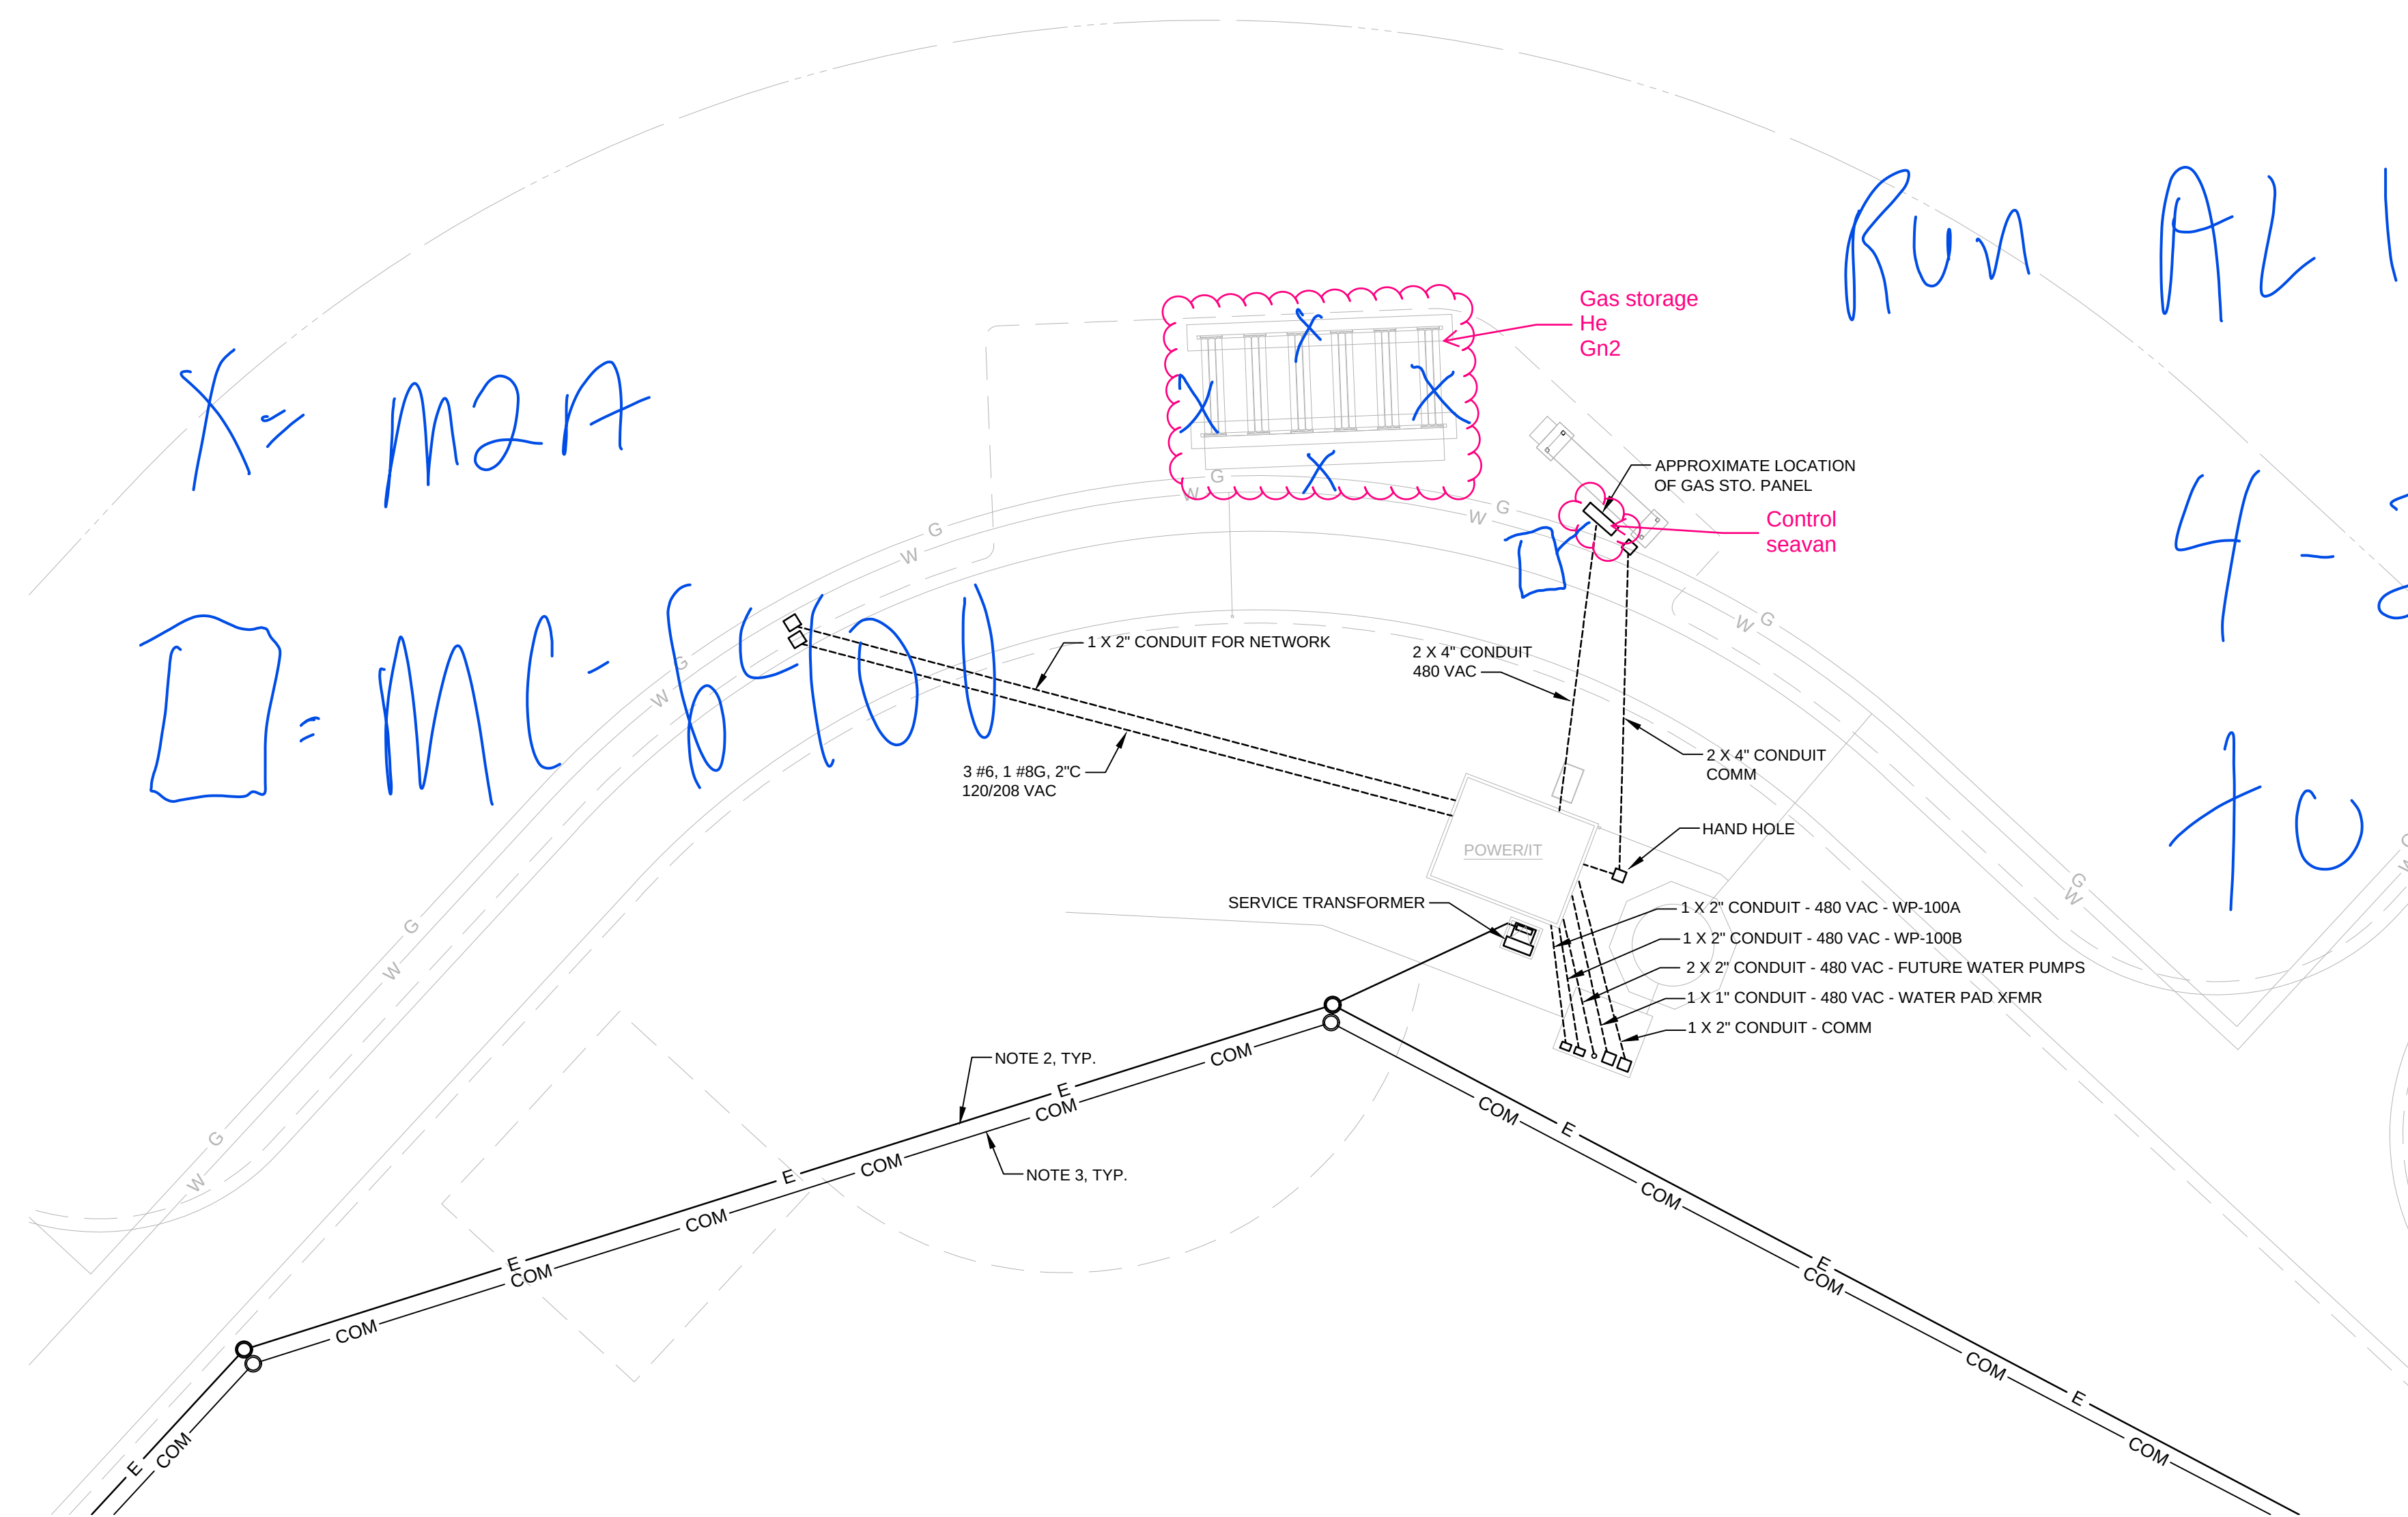

ELECTRICAL SITE PLAN - WATER PAD AREA

SCALE: 1" = 30'

- # PLAN NOTES

1. LOW VOLTAGE (UNDER 600 VOLTS) FEEDER CONDUITS AND CONDUITS FROM BUILDING TO END HAND-HOLES SHALL BE DIRECTLY BURIED SCHEDULE 40 PVC WITH 24" COVER MINIMUM.
2. MEDIUM VOLTAGE CONDUITS ARE UNDER A SEPARATE PROJECT AND SHALL BE CONCRETE ENCASED.
3. MAIN COMMUNICATIONS DUCTBANKS ARE UNDER A SEPARATE PROJECT AND SHALL BE CONCRETE ENCASED.
4. HAND HOLES SHALL BE SIZED AND SPECIFIED BY RELATIVITY.
5. ROUTING AND LOCATIONS ARE APPROXIMATE, EXACT ROUTING AND LOCATIONS SHALL BE FIELD-COORDINATED WITH RELATIVITY.